



HATCH OPNG FRAME, TYP
SEE STD DET, SHT ZOS02

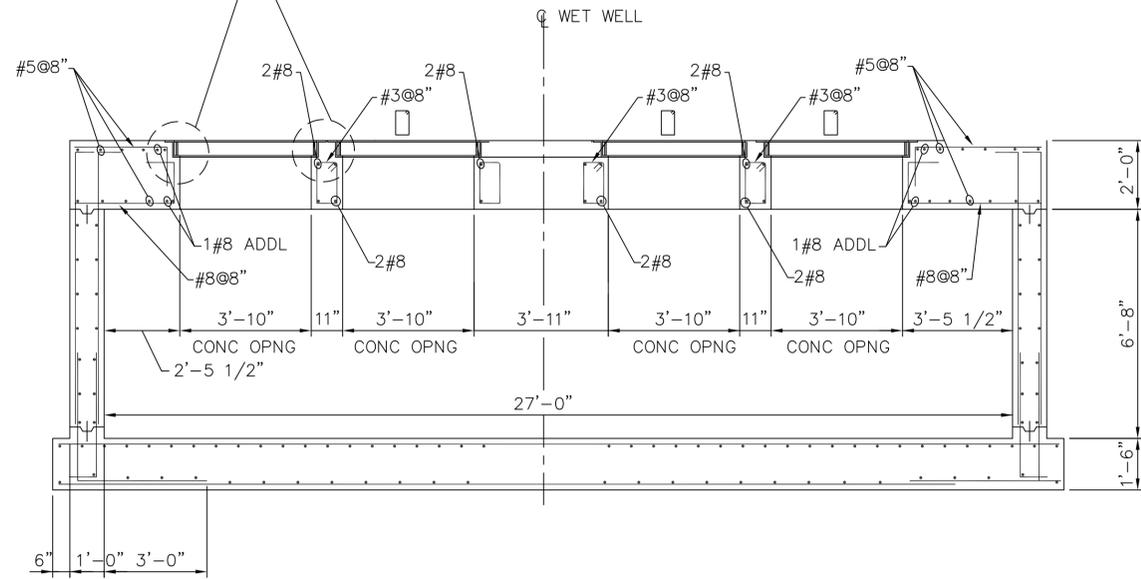

SECTION B
J3S01


HATCH OPNG FRAME, TYP
SEE STD DET, SHT ZOS02

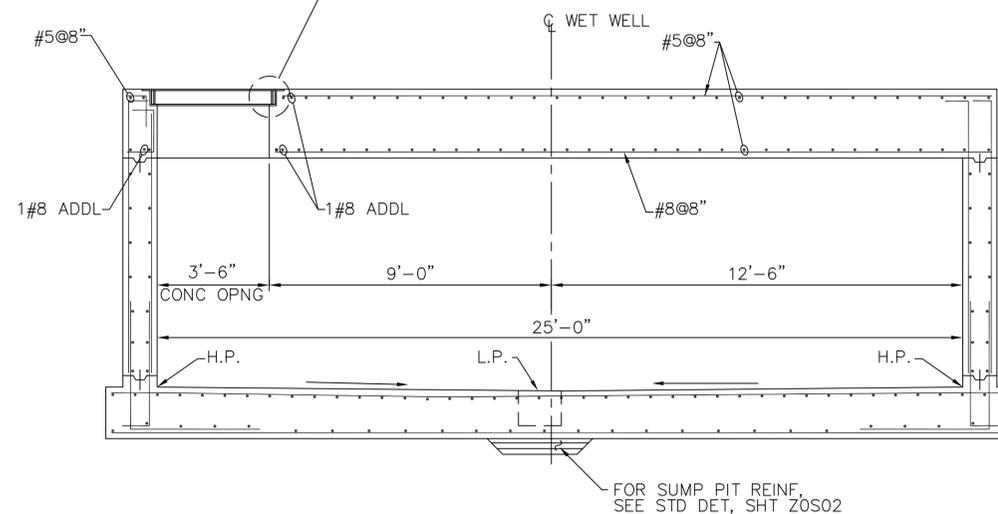


SECTION C
J3S01

FOR SUMP PIT REINF.
SEE STD DET, SHT ZOS02

HATCH OPNG FRAME, TYP
SEE STD DET, SHT ZOS02

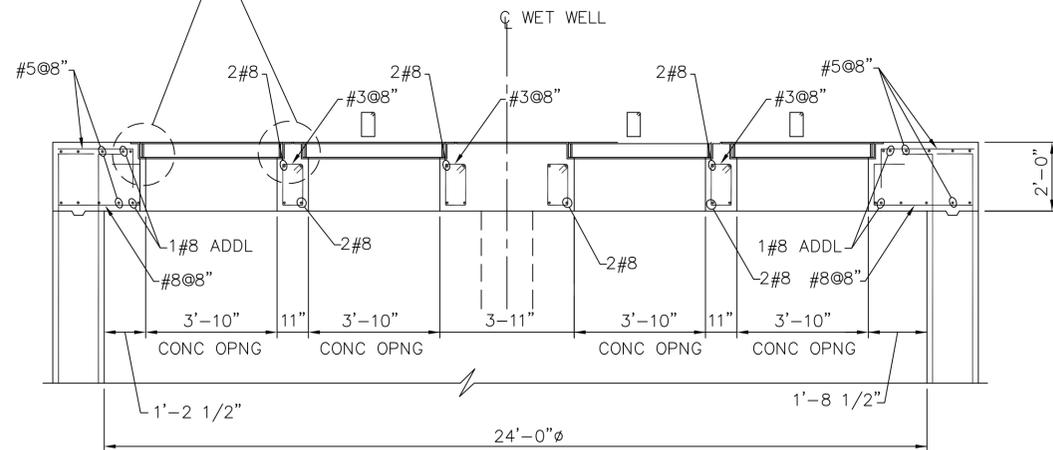

SECTION D
J3S01

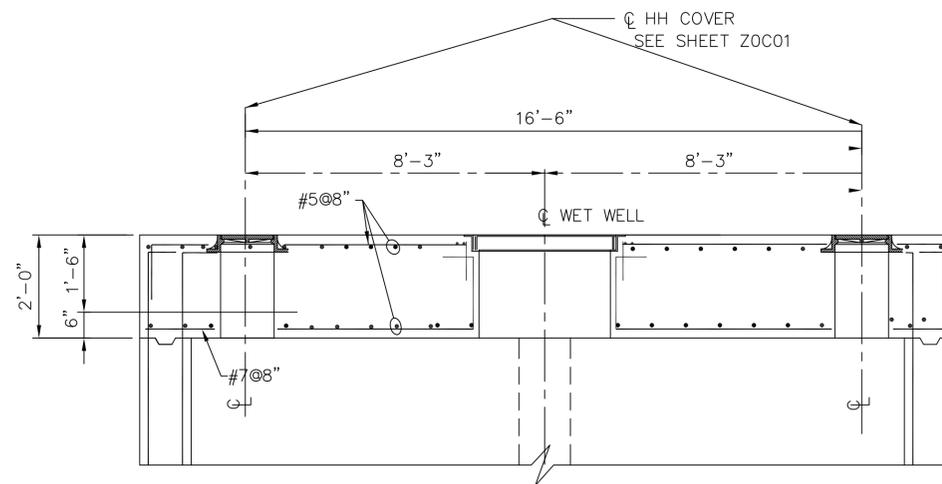

SECTION E
J3S01

NOTES TO DESIGN ENGINEER:

- A. THESE LIFT STATION DRAWINGS ARE CONSIDERED TO BE DESIGN GUIDELINES FOR THE CONSTRUCTION OF CITY OF HOUSTON WASTEWATER SUBMERSIBLE LIFT STATIONS. THEIR INTENDED USE IS AS A FRAMEWORK FOR THE CONTRACTED DESIGN ENGINEER IN DEVELOPING SPECIFIC LIFT STATION DESIGNS. IT IS THE RESPONSIBILITY OF THE CONTRACTED DESIGN ENGINEER TO VERIFY THE COMPLETENESS AND ACCURACY OF THE INFORMATION HEREBIN CONTAINED AND TO ADJUST ACCORDING TO PROJECT SPECIFIC REQUIREMENTS.
- B. DESIGN ENGINEER TO VERIFY SIZE AND LOCATION OF THE ACCESS HATCH OPENINGS PER SELECTED HATCH AND PUMP MANUFACTURERS' REQUIREMENTS.
- C. SEE DETAIL AND CIVIL DRAWINGS FOR DIMENSIONS AND INFORMATION NOT SHOWN.
- D. THE DESIGN ENGINEER SHALL INCORPORATE ONLY THE NECESSARY STANDARD GUIDELINE DRAWINGS AND DETAILS INTO HIS PROJECT CONTRACT DOCUMENTATION PACKAGE, AND SHALL ADJUST PACE NUMBERS AND CROSS REFERENCING ACCORDINGLY.
- E. THE DESIGN ENGINEER SHALL CONSULT THE CITY OF HOUSTON DESIGN GUIDELINES MANUAL, THE ENGINEERING DESIGN MANUAL, AND THE MASTER SPECIFICATIONS FOR FURTHER INSTRUCTIONS AND INFORMATION PERTINENT TO THESE STANDARD DESIGN GUIDELINE DRAWINGS.
- F. THE DESIGN ENGINEER SHALL REMOVE THESE NOTES, ALL REFERENCES TO THESE NOTES, AND ANY OTHER EXTRANEOUS INFORMATION FROM THE DESIGN GUIDELINE DRAWINGS. DESIGN ENGINEER SHALL PROVIDE ANY NOTES OR OTHER APPROPRIATE INFORMATION NECESSARY TO COMPLETE THE LIFT STATION DESIGN.

NOTES:

1. FOR ADDITIONAL REINFORCEMENT AT OPENINGS NOT SHOWN, SEE SHEET ZOS01.
2. CONTRACTOR TO CONFIRM THE SIZE AND LOCATION OF THE ACCESS HATCH OPENINGS PER SELECTED HATCH AND PUMP MANUFACTURERS' REQUIREMENTS.
3. SEE DETAIL AND CIVIL DRAWINGS FOR DIMENSIONS AND INFORMATION NOT SHOWN.

STRUCTURAL
4 PUMPS @ 800 - 3499 GPM PER PUMP
ALTERNATE LOW PROFILE CONFIGURATION

PROJECT NO. R-000267-0XXX-X

TITLE CITY OF HOUSTON
DESIGN GUIDELINE DRAWINGS
FOR SUBMERSIBLE LIFT STATIONS

CITY OF HOUSTON
DEPARTMENT OF PUBLIC WORKS AND ENGINEERING
ENGINEERING AND CONSTRUCTION

DESIGN ENGINEER TO INCLUDE COH
STANDARD TITLE BLOCK ON ALL
DRAWINGS, SEE STANDARD TITLE
BLOCK DETAIL ON SHEET ZOCOX

SCALE: xx" = 1'-0"
DESIGNED BY:
DRAWN BY:
DATE: MARCH, 2013 SHEET NO. OF SHEETS
SURVEY BY: DWG. NO.
FIELD BOOK NO. J3S04

| REV. NO. | DESCRIPTION | APP'D | DATE |
|----------|-------------|-------|------|
| | | | |
| | | | |
| | | | |
| | | | |

CADD DWG. FILE NO. : J3S04.DWG

NOTES TO DESIGN ENGINEER:

- A. THESE LIFT STATION DRAWINGS ARE CONSIDERED TO BE DESIGN GUIDELINES FOR THE CONSTRUCTION OF CITY OF HOUSTON WASTEWATER SUBMERSIBLE LIFT STATIONS. THEIR INTENDED USE IS AS A FRAMEWORK FOR THE CONTRACTED DESIGN ENGINEER IN DEVELOPING SPECIFIC LIFT STATION DESIGNS. IT IS THE RESPONSIBILITY OF THE CONTRACTED DESIGN ENGINEER TO VERIFY THE COMPLETENESS AND ACCURACY OF THE INFORMATION HEREIN CONTAINED AND TO ADJUST ACCORDING TO PROJECT SPECIFIC REQUIREMENTS.
- B. DESIGN ENGINEER TO VERIFY SIZE AND LOCATION OF THE ACCESS HATCH OPENINGS PER SELECTED HATCH AND PUMP MANUFACTURERS' REQUIREMENTS.
- C. DIMENSIONS, ELEVATIONS AND REINFORCING NOT PROVIDED ARE TO BE DETERMINED BY THE DESIGN ENGINEER PER APPLICABLE PROJECT SPECIFIC REQUIREMENTS.
- D. SEE DETAIL AND CIVIL DRAWINGS FOR DIMENSIONS AND INFORMATION NOT SHOWN.
- E. DESIGN ENGINEER TO PROVIDE WET WELL DESIGN FOR EITHER OPEN-CUT OR CAISSON CONSTRUCTION.
- F. THE DESIGN ENGINEER SHALL INCORPORATE ONLY THE NECESSARY STANDARD GUIDELINE DRAWINGS AND DETAILS INTO HIS PROJECT CONTRACT DOCUMENTATION PACKAGE, AND SHALL ADJUST PAGE NUMBERS AND CROSS REFERENCING ACCORDINGLY.
- G. THE DESIGN ENGINEER SHALL CONSULT THE CITY OF HOUSTON DESIGN GUIDELINES MANUAL, THE ENGINEERING DESIGN MANUAL, AND THE MASTER SPECIFICATIONS FOR FURTHER INSTRUCTIONS AND INFORMATION PERTINENT TO THESE STANDARD DESIGN GUIDELINE DRAWINGS.
- H. THE DESIGN ENGINEER SHALL REMOVE THESE NOTES, ALL REFERENCES TO THESE NOTES, AND ANY OTHER EXTRANEOUS INFORMATION FROM THE DESIGN GUIDELINE DRAWINGS. DESIGN ENGINEER SHALL PROVIDE ANY NOTES OR OTHER APPROPRIATE INFORMATION NECESSARY TO COMPLETE THE LIFT STATION DESIGN.

NOTES:

- 1. FOR ADDITIONAL REINFORCEMENT AT OPENINGS NOT SHOWN, SEE SHEET ZOS01.
- 2. CONTRACTOR TO CONFIRM SIZE AND LOCATION OF THE ACCESS HATCH OPENINGS PER SELECTED HATCH AND PUMP MANUFACTURERS' REQUIREMENTS.
- 3. DIMENSIONS NOTED ARE RELATIVE TO THE PUMP SIZE AND MANUFACTURER SELECTED. CONTRACTOR SHALL CONFIRM.
- 4. SEE DETAIL AND CIVIL DRAWINGS FOR DIMENSIONS AND INFORMATION NOT SHOWN.
- 5. WET WELL TO BE LINED WITH CONCRETE PROTECTIVE LINER PER PROJECT SPECIFICATIONS, CONSULT WITH COH PROJECT MANAGER FOR APPROVED PRODUCTS. LINER SHALL COVER ALL CONCRETE SURFACES, AND SHALL EXTEND TO A MINIMUM OF 12" BELOW THE LOW WATER ELEVATION.

STRUCTURAL
4 PUMPS @ 800 - 3499 GPM PER PUMP
ALTERNATE LOW PROFILE CONFIGURATION


PROJECT NO. R-000267-0XXX-X

TITLE CITY OF HOUSTON
DESIGN GUIDELINE DRAWINGS
FOR SUBMERSIBLE LIFT STATIONS

CITY OF HOUSTON
DEPARTMENT OF PUBLIC WORKS AND ENGINEERING
ENGINEERING AND CONSTRUCTION

DESIGN ENGINEER TO INCLUDE COH STANDARD TITLE BLOCK ON ALL DRAWINGS, SEE STANDARD TITLE BLOCK DETAIL ON SHEET ZOC0X


SCALE: xx" = 1'-0"
DESIGNED BY:
SUBMITTED: DRAWN BY:
DATE: MARCH, 2013 SHEET NO. OF SHEETS
SURVEY BY: DWG. NO.
FIELD BOOK NO. J3S03

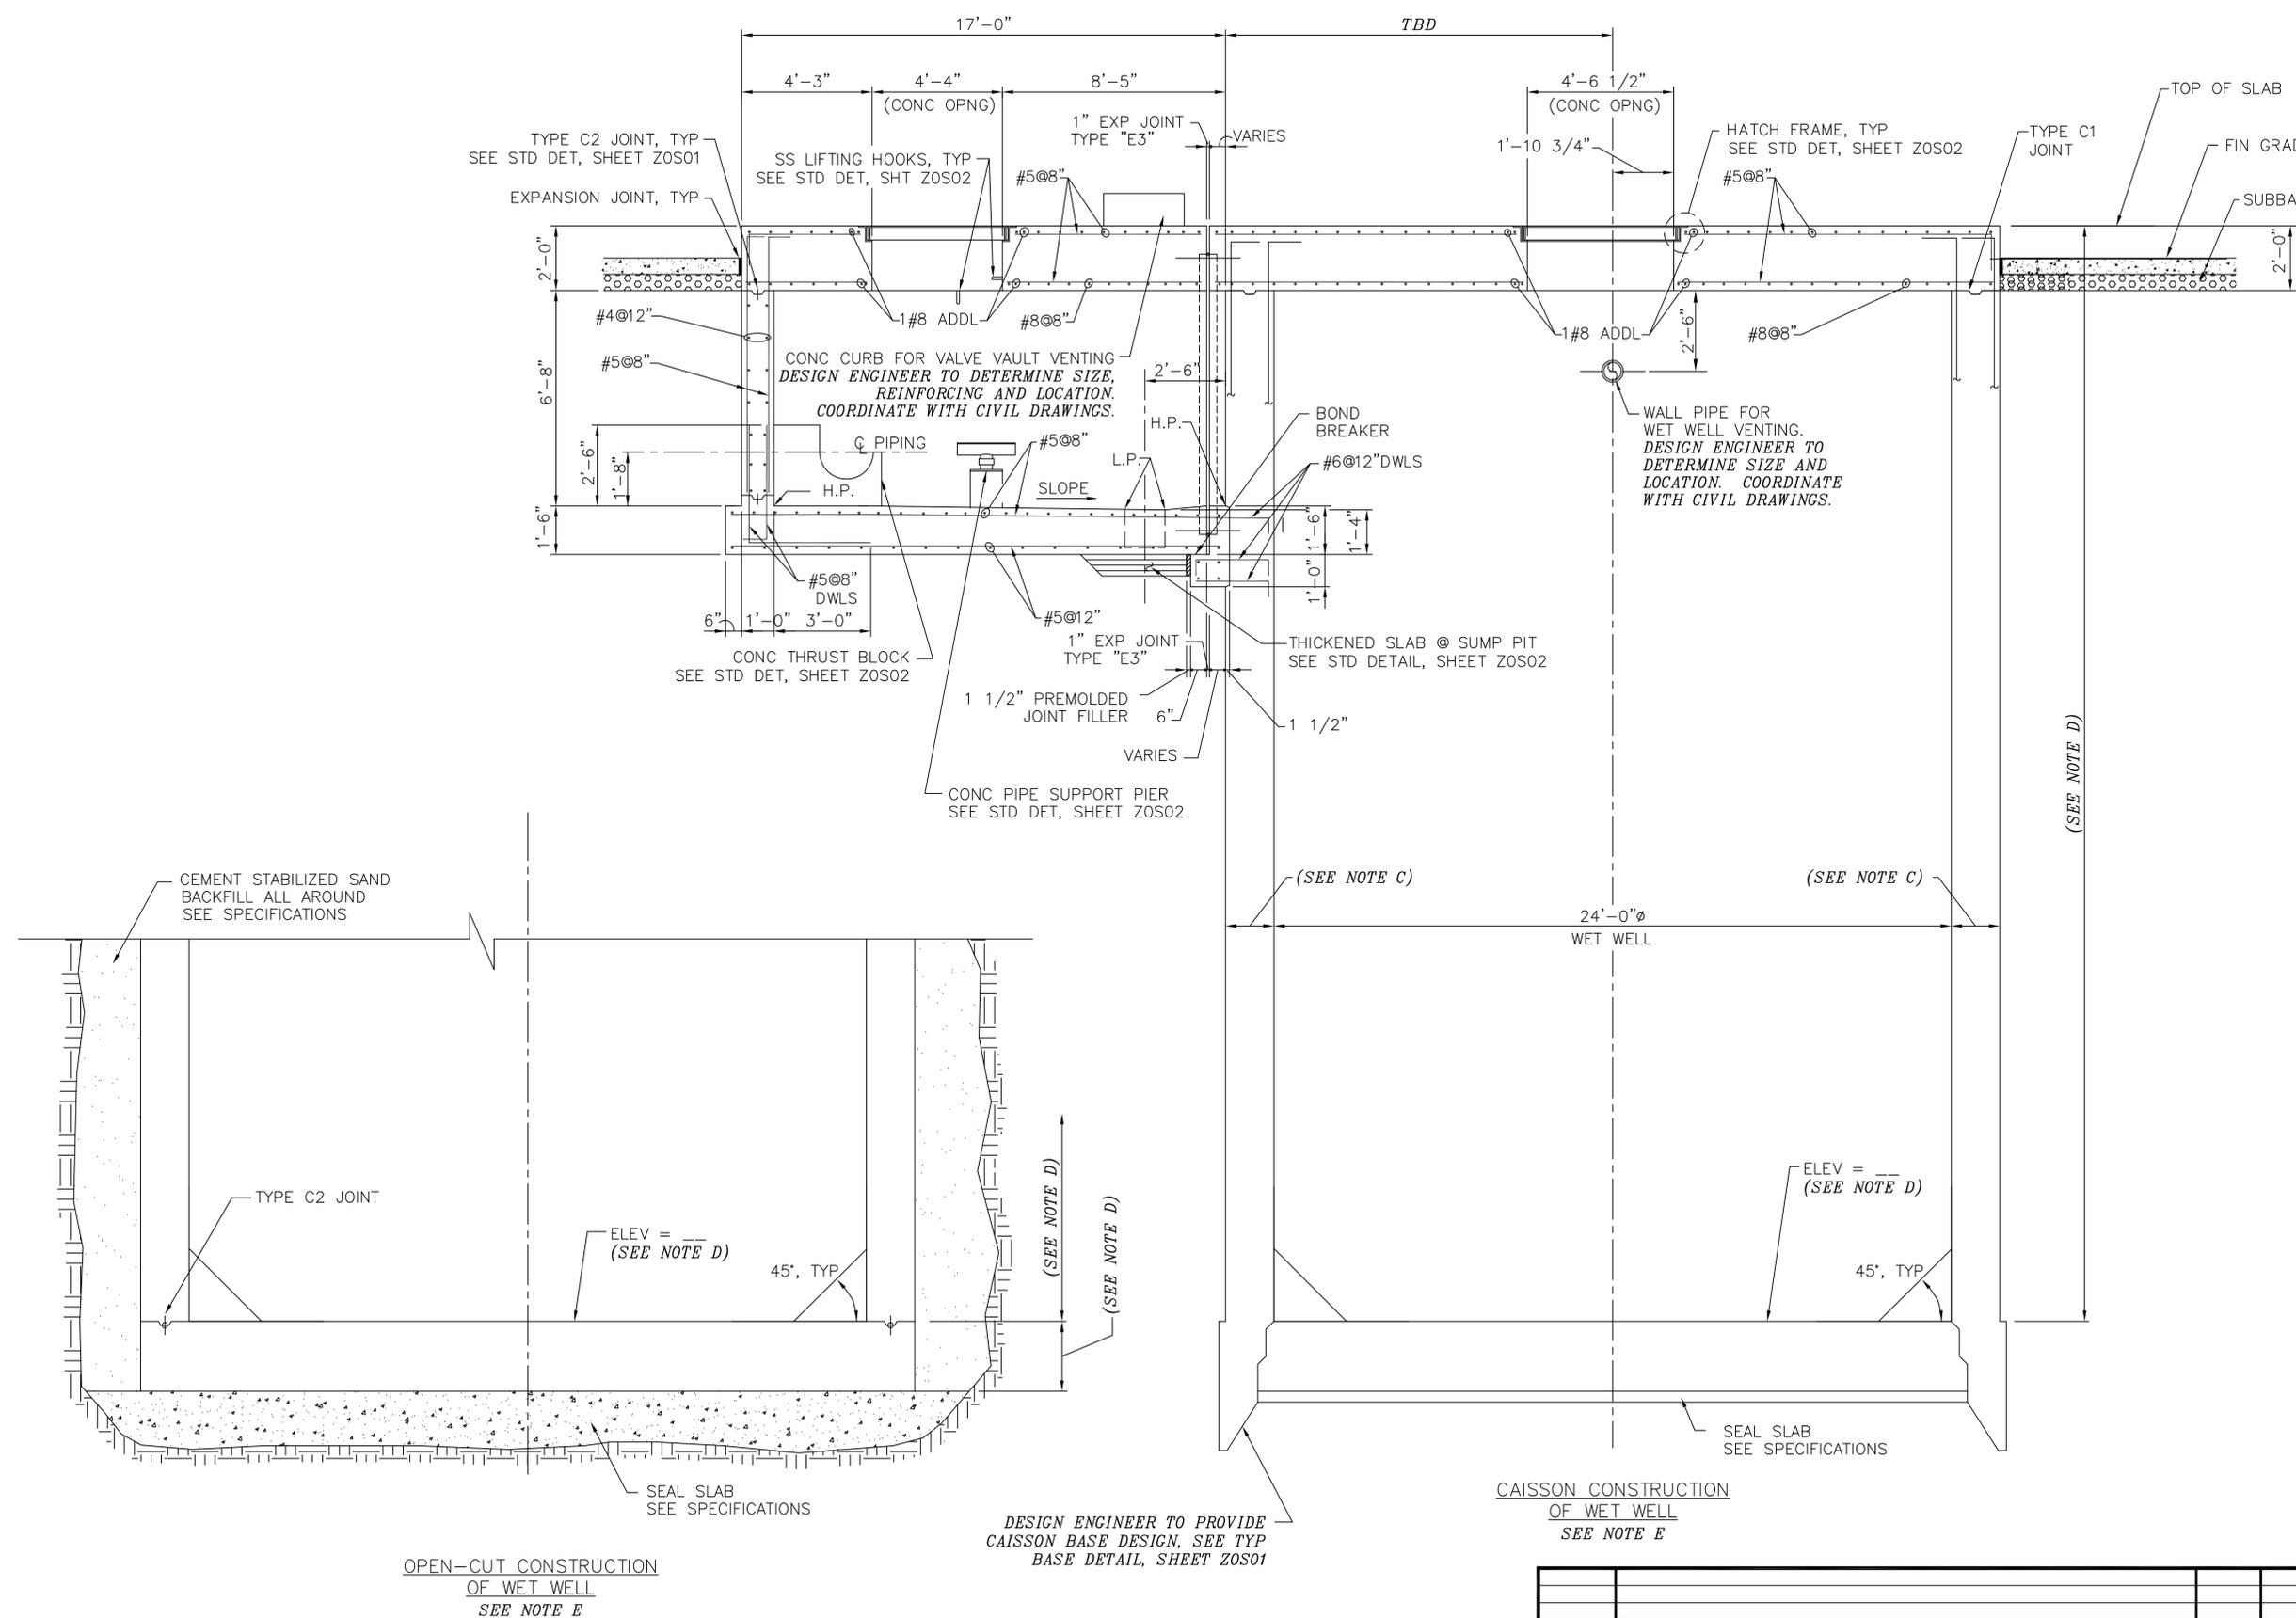

SECTION A
13S01

| REV. NO. | DESCRIPTION | APP'D | DATE |
|----------|-------------|-------|------|
| | | | |
| | | | |
| | | | |
| | | | |

CADD DWG. FILE NO. : J3S03.DWG

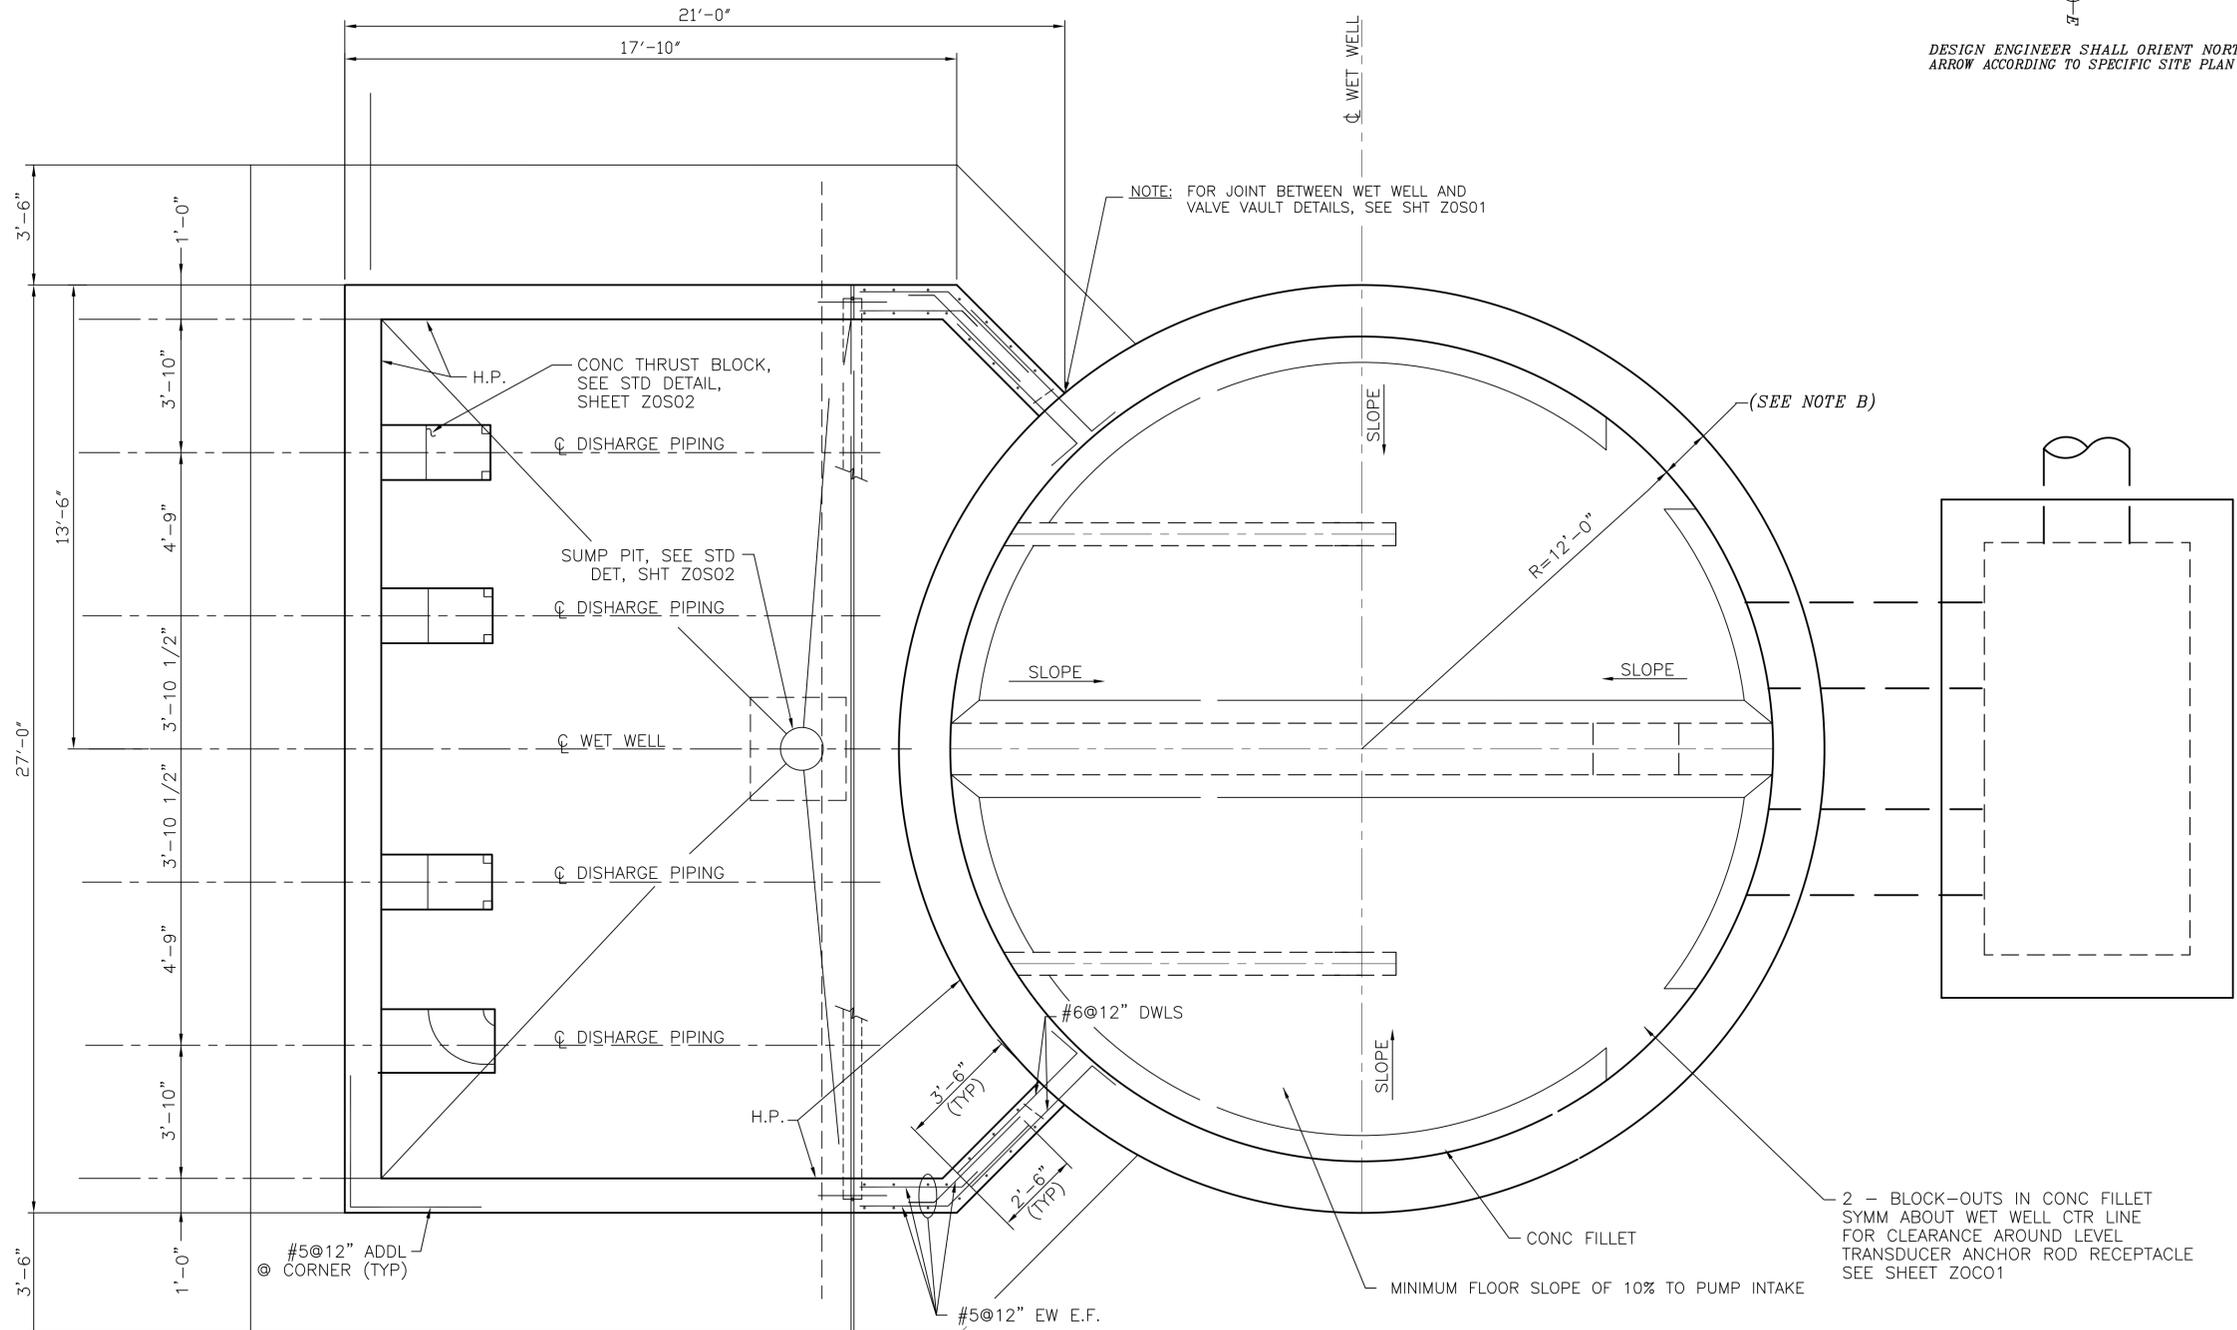

DESIGN ENGINEER SHALL ORIENT NORTH
ARROW ACCORDING TO SPECIFIC SITE PLAN

NOTES TO DESIGN ENGINEER:

A. THESE LIFT STATION DRAWINGS ARE CONSIDERED TO BE DESIGN GUIDELINES FOR THE CONSTRUCTION OF CITY OF HOUSTON WASTEWATER SUBMERSIBLE LIFT STATIONS. THEIR INTENDED USE IS AS A FRAMEWORK FOR THE CONTRACTED DESIGN ENGINEER IN DEVELOPING SPECIFIC LIFT STATION DESIGNS. IT IS THE RESPONSIBILITY OF THE CONTRACTED DESIGN ENGINEER TO VERIFY THE COMPLETENESS AND ACCURACY OF THE INFORMATION HEREIN CONTAINED AND TO ADJUST ACCORDING TO PROJECT SPECIFIC REQUIREMENTS.

B. DIMENSIONS AND REINFORCING NOT PROVIDED ARE TO BE DETERMINED BY THE DESIGN ENGINEER PER APPLICABLE SITE REQUIREMENTS.

C. SEE DETAIL AND CIVIL DRAWINGS FOR DIMENSIONS AND INFORMATION NOT SHOWN.

D. THE DESIGN ENGINEER SHALL INCORPORATE ONLY THE NECESSARY STANDARD GUIDELINE DRAWINGS AND DETAILS INTO HIS PROJECT CONTRACT DOCUMENTATION PACKAGE, AND SHALL ADJUST PAGE NUMBERS AND CROSS REFERENCING ACCORDINGLY.

E. THE DESIGN ENGINEER SHALL CONSULT THE CITY OF HOUSTON DESIGN GUIDELINES MANUAL, THE ENGINEERING DESIGN MANUAL, AND THE MASTER SPECIFICATIONS FOR FURTHER INSTRUCTIONS AND INFORMATION PERTINENT TO THESE STANDARD DESIGN GUIDELINE DRAWINGS.

F. THE DESIGN ENGINEER SHALL REMOVE THESE NOTES, ALL REFERENCES TO THESE NOTES, AND ANY OTHER EXTRANEOUS INFORMATION FROM THE DESIGN GUIDELINE DRAWINGS. DESIGN ENGINEER SHALL PROVIDE ANY NOTES OR OTHER APPROPRIATE INFORMATION NECESSARY TO COMPLETE THE LIFT STATION DESIGN.

- NOTES:**
- FOR ADDITIONAL REINFORCEMENT AT OPENINGS NOT SHOWN, SEE SHEET ZOS01.
 - DIMENSIONS NOTED ARE RELATIVE TO THE PUMP SIZE AND MANUFACTURER SELECTED. CONTRACTOR SHALL CONFIRM.
 - SEE DETAIL AND CIVIL DRAWINGS FOR DIMENSIONS AND INFORMATION NOT SHOWN.
 - WET WELL TO BE LINED WITH CONCRETE PROTECTIVE LINER PER PROJECT SPECIFICATIONS, CONSULT WITH COH PROJECT MANAGER FOR APPROVED PRODUCTS. LINER SHALL COVER ALL CONCRETE SURFACES, AND SHALL EXTEND TO A MINIMUM OF 12" BELOW THE LOW WATER ELEVATION.

STRUCTURAL
4 PUMPS @ 800 - 3499 GPM PER PUMP
ALTERNATE LOW PROFILE CONFIGURATION

PROJECT NO. R-000267-0XXX-X

TITLE CITY OF HOUSTON
DESIGN GUIDELINE DRAWINGS
FOR SUBMERSIBLE LIFT STATIONS

CITY OF HOUSTON
DEPARTMENT OF PUBLIC WORKS AND ENGINEERING
ENGINEERING AND CONSTRUCTION

DESIGN ENGINEER TO INCLUDE COH
STANDARD TITLE BLOCK ON ALL
DRAWINGS, SEE STANDARD TITLE
BLOCK DETAIL ON SHEET ZOC0X


PLAN VIEW @ VAULT FLOOR

| REV. NO. | DESCRIPTION | APP'D | DATE |
|----------|-------------|-------|------|
| | | | |
| | | | |
| | | | |
| | | | |

SCALE: XX" = 1'-0"
DESIGNED BY:
SUBMITTED: DRAWN BY:
DATE: MARCH, 2013 SHEET NO. OF SHEETS
SURVEY BY: DWG. NO. J3S02
FIELD BOOK NO.

CADD DWG. FILE NO. : J3S02.DWG

14"Ø D.I.P. WALL PIPE W/ CURB FOR VALVE VAULT VENTING. DESIGN ENGINEER TO DETERMINE SIZE, REINFORCING AND LOCATION. COORDINATE WITH CIVIL DRAWINGS.

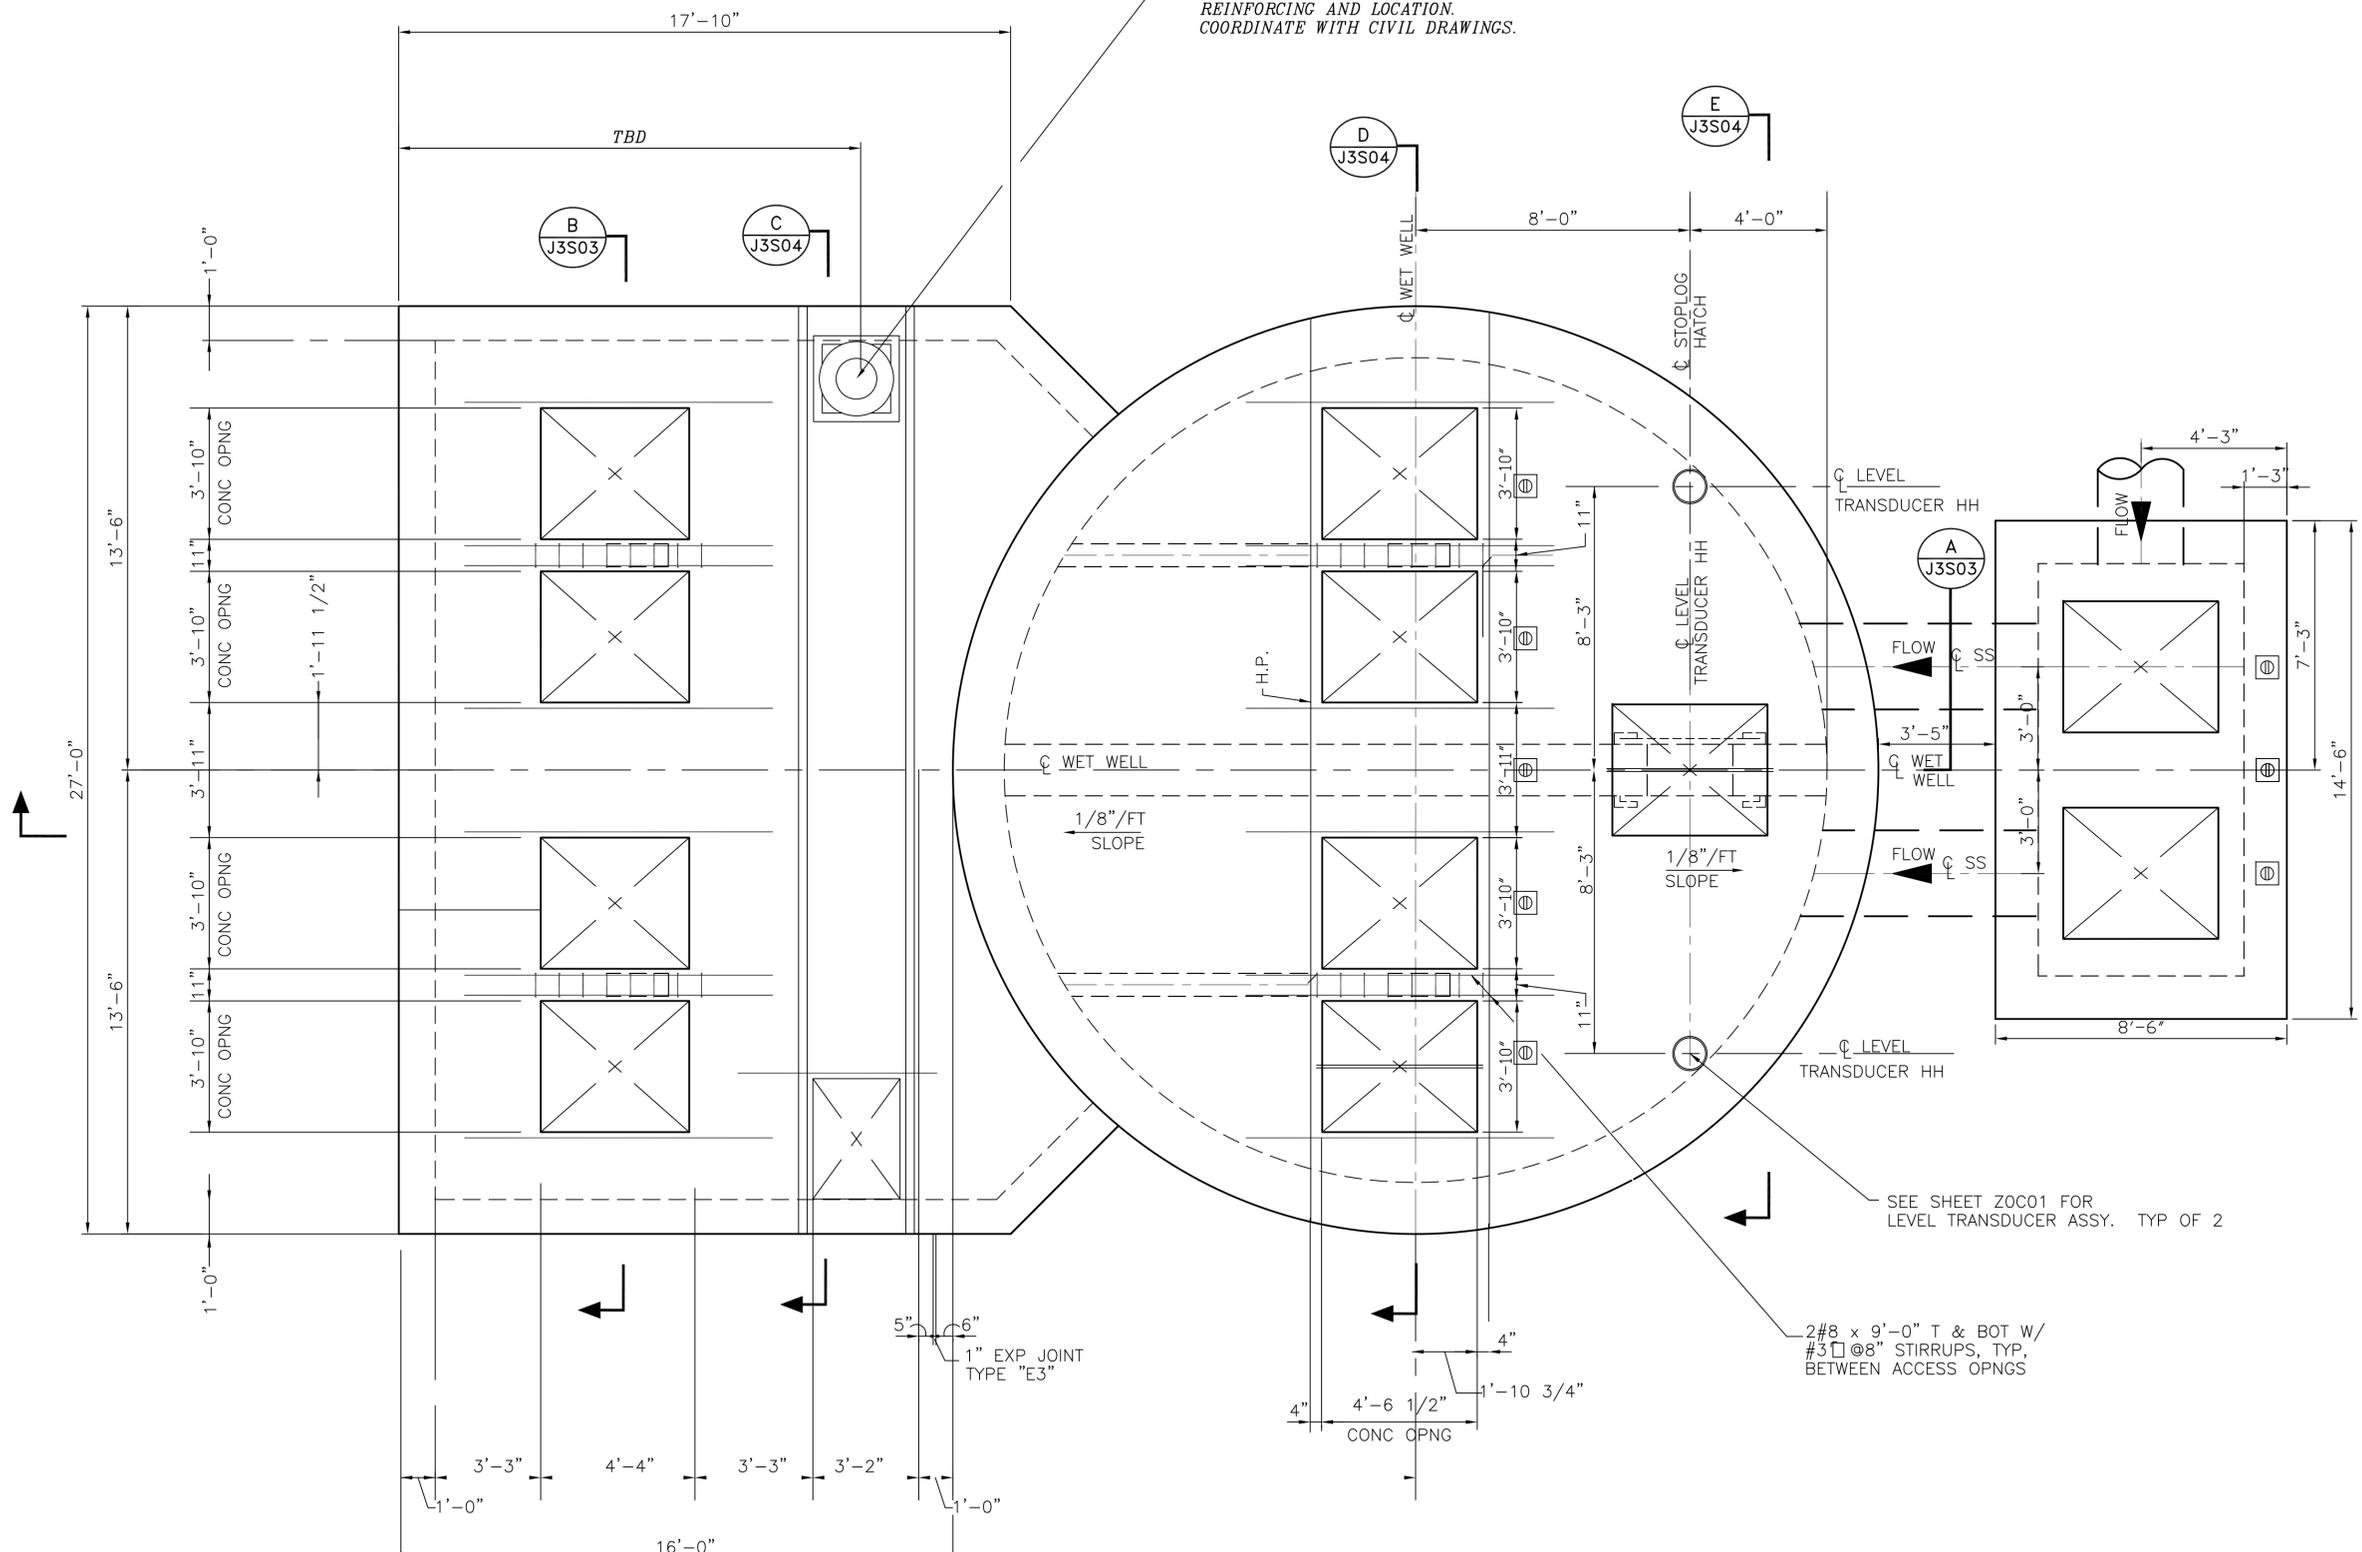

PLAN VIEW @ GRADE

- NOTES TO DESIGN ENGINEER:**
- THESE LIFT STATION DRAWINGS ARE CONSIDERED TO BE DESIGN GUIDELINES FOR THE CONSTRUCTION OF CITY OF HOUSTON WASTEWATER SUBMERSIBLE LIFT STATIONS. THEIR INTENDED USE IS AS A FRAMEWORK FOR THE CONTRACTED DESIGN ENGINEER IN DEVELOPING SPECIFIC LIFT STATION DESIGNS. IT IS THE RESPONSIBILITY OF THE CONTRACTED DESIGN ENGINEER TO VERIFY THE COMPLETENESS AND ACCURACY OF THE INFORMATION HEREIN CONTAINED AND TO ADJUST ACCORDING TO PROJECT SPECIFIC REQUIREMENTS.
 - DESIGN ENGINEER TO VERIFY SIZE AND LOCATION OF THE ACCESS HATCH OPENINGS PER SELECTED HATCH AND PUMP MANUFACTURERS' REQUIREMENTS.
 - DIMENSIONS NOTED ARE RELATIVE TO THE PUMP SIZE AND MANUFACTURER SELECTED. DESIGN ENGINEER SHALL VERIFY.
 - DIMENSIONS AND REINFORCING NOT PROVIDED ARE TO BE DETERMINED BY THE DESIGN ENGINEER PER APPLICABLE SITE REQUIREMENTS.
 - SEE DETAIL AND CIVIL DRAWINGS FOR DIMENSIONS AND INFORMATION NOT SHOWN.
 - THE DESIGN ENGINEER SHALL INCORPORATE ONLY THE NECESSARY STANDARD GUIDELINE DRAWINGS AND DETAILS INTO HIS PROJECT CONTRACT DOCUMENTATION PACKAGE, AND SHALL ADJUST PAGE NUMBERS AND CROSS REFERENCING ACCORDINGLY.
 - THE DESIGN ENGINEER SHALL CONSULT THE CITY OF HOUSTON DESIGN GUIDELINES MANUAL, THE ENGINEERING DESIGN MANUAL, AND THE MASTER SPECIFICATIONS FOR FURTHER INSTRUCTIONS AND INFORMATION PERTINENT TO THESE STANDARD DESIGN GUIDELINE DRAWINGS.
 - THE DESIGN ENGINEER SHALL REMOVE THESE NOTES, ALL REFERENCES TO THESE NOTES, AND ANY OTHER EXTRANEOUS INFORMATION FROM THE DESIGN GUIDELINE DRAWINGS. DESIGN ENGINEER SHALL PROVIDE ANY NOTES OR OTHER APPROPRIATE INFORMATION NECESSARY TO COMPLETE THE LIFT STATION DESIGN.
 - THE DESIGN ENGINEER SHALL ENSURE GUARDRAIL AND CATWALK MEET THE REQUIREMENTS FOR "AREAS NOT OPEN TO PUBLIC" AS PROVIDED BY THE U.S. OCCUPATIONAL SAFETY & HEALTH ADMINISTRATION (OSHA) AND LATEST COH CODE ENFORCEMENT APPROVED VERSION OF THE INTERNATIONAL BUILDING CODE (IBC).
 - THE DESIGN ENGINEER SHALL PROVIDE GUARDRAILS FOR ANY WALKING SURFACES WITH A POTENTIAL FALL DISTANCE EQUAL TO OR GREATER THAN 30 INCHES.

- NOTES:**
- FOR ADDITIONAL REINFORCEMENT AT OPENINGS NOT SHOWN, SEE SHEET ZOS01.
 - CONTRACTOR TO CONFIRM SIZE AND LOCATION OF THE ACCESS HATCH OPENINGS PER SELECTED HATCH AND PUMP MANUFACTURERS' REQUIREMENTS.
 - DIMENSIONS NOTED ARE RELATIVE TO THE PUMP SIZE AND MANUFACTURER SELECTED. CONTRACTOR SHALL CONFIRM.
 - SEE DETAIL AND CIVIL DRAWINGS FOR DIMENSIONS AND INFORMATION NOT SHOWN.
 - WET WELL TO BE LINED WITH CONCRETE PROTECTIVE LINER PER PROJECT SPECIFICATIONS, CONSULT WITH COH PROJECT MANAGER FOR APPROVED PRODUCTS. LINER SHALL COVER ALL CONCRETE SURFACES, AND SHALL EXTEND TO A MINIMUM OF 12" BELOW THE LOW WATER ELEVATION.

STRUCTURAL
 4 PUMPS @ 800 -3499 GPM PER PUMP
 ALTERNATE LOW PROFILE CONFIGURATION

PROJECT NO. R-000267-0XXX-X

TITLE CITY OF HOUSTON
 DESIGN GUIDELINE DRAWINGS
 FOR SUBMERSIBLE LIFT STATIONS

CITY OF HOUSTON
 DEPARTMENT OF PUBLIC WORKS AND ENGINEERING
 ENGINEERING AND CONSTRUCTION

DESIGN ENGINEER TO INCLUDE COH STANDARD TITLE BLOCK ON ALL DRAWINGS, SEE STANDARD TITLE BLOCK DETAIL ON SHEET ZOC0X


| | | | |
|----------------|----------------|---------------------|-------|
| SCALE: | XX" = 1'-0" | DESIGNED BY: | |
| SUBMITTED: | | DRAWN BY: | |
| DATE: | NOVEMBER, 1996 | SHEET NO. OF SHEETS | |
| SURVEY BY: | | DWG. NO. | J3S01 |
| FIELD BOOK NO. | | | |

| REV. NO. | DESCRIPTION | APP'D | DATE |
|----------|-------------|-------|------|
| | | | |
| | | | |
| | | | |
| | | | |

CADD DWG. FILE NO. : J3S01.DWG

COHSTD.BDR 0 1 2 3 ORIGINAL SCALE IN INCHES FOR REDUCED PLANS

DESIGN ENGINEER TO UPDATE BAR SCALE TO REFLECT ACTUAL SCALE ON THE DRAWING.

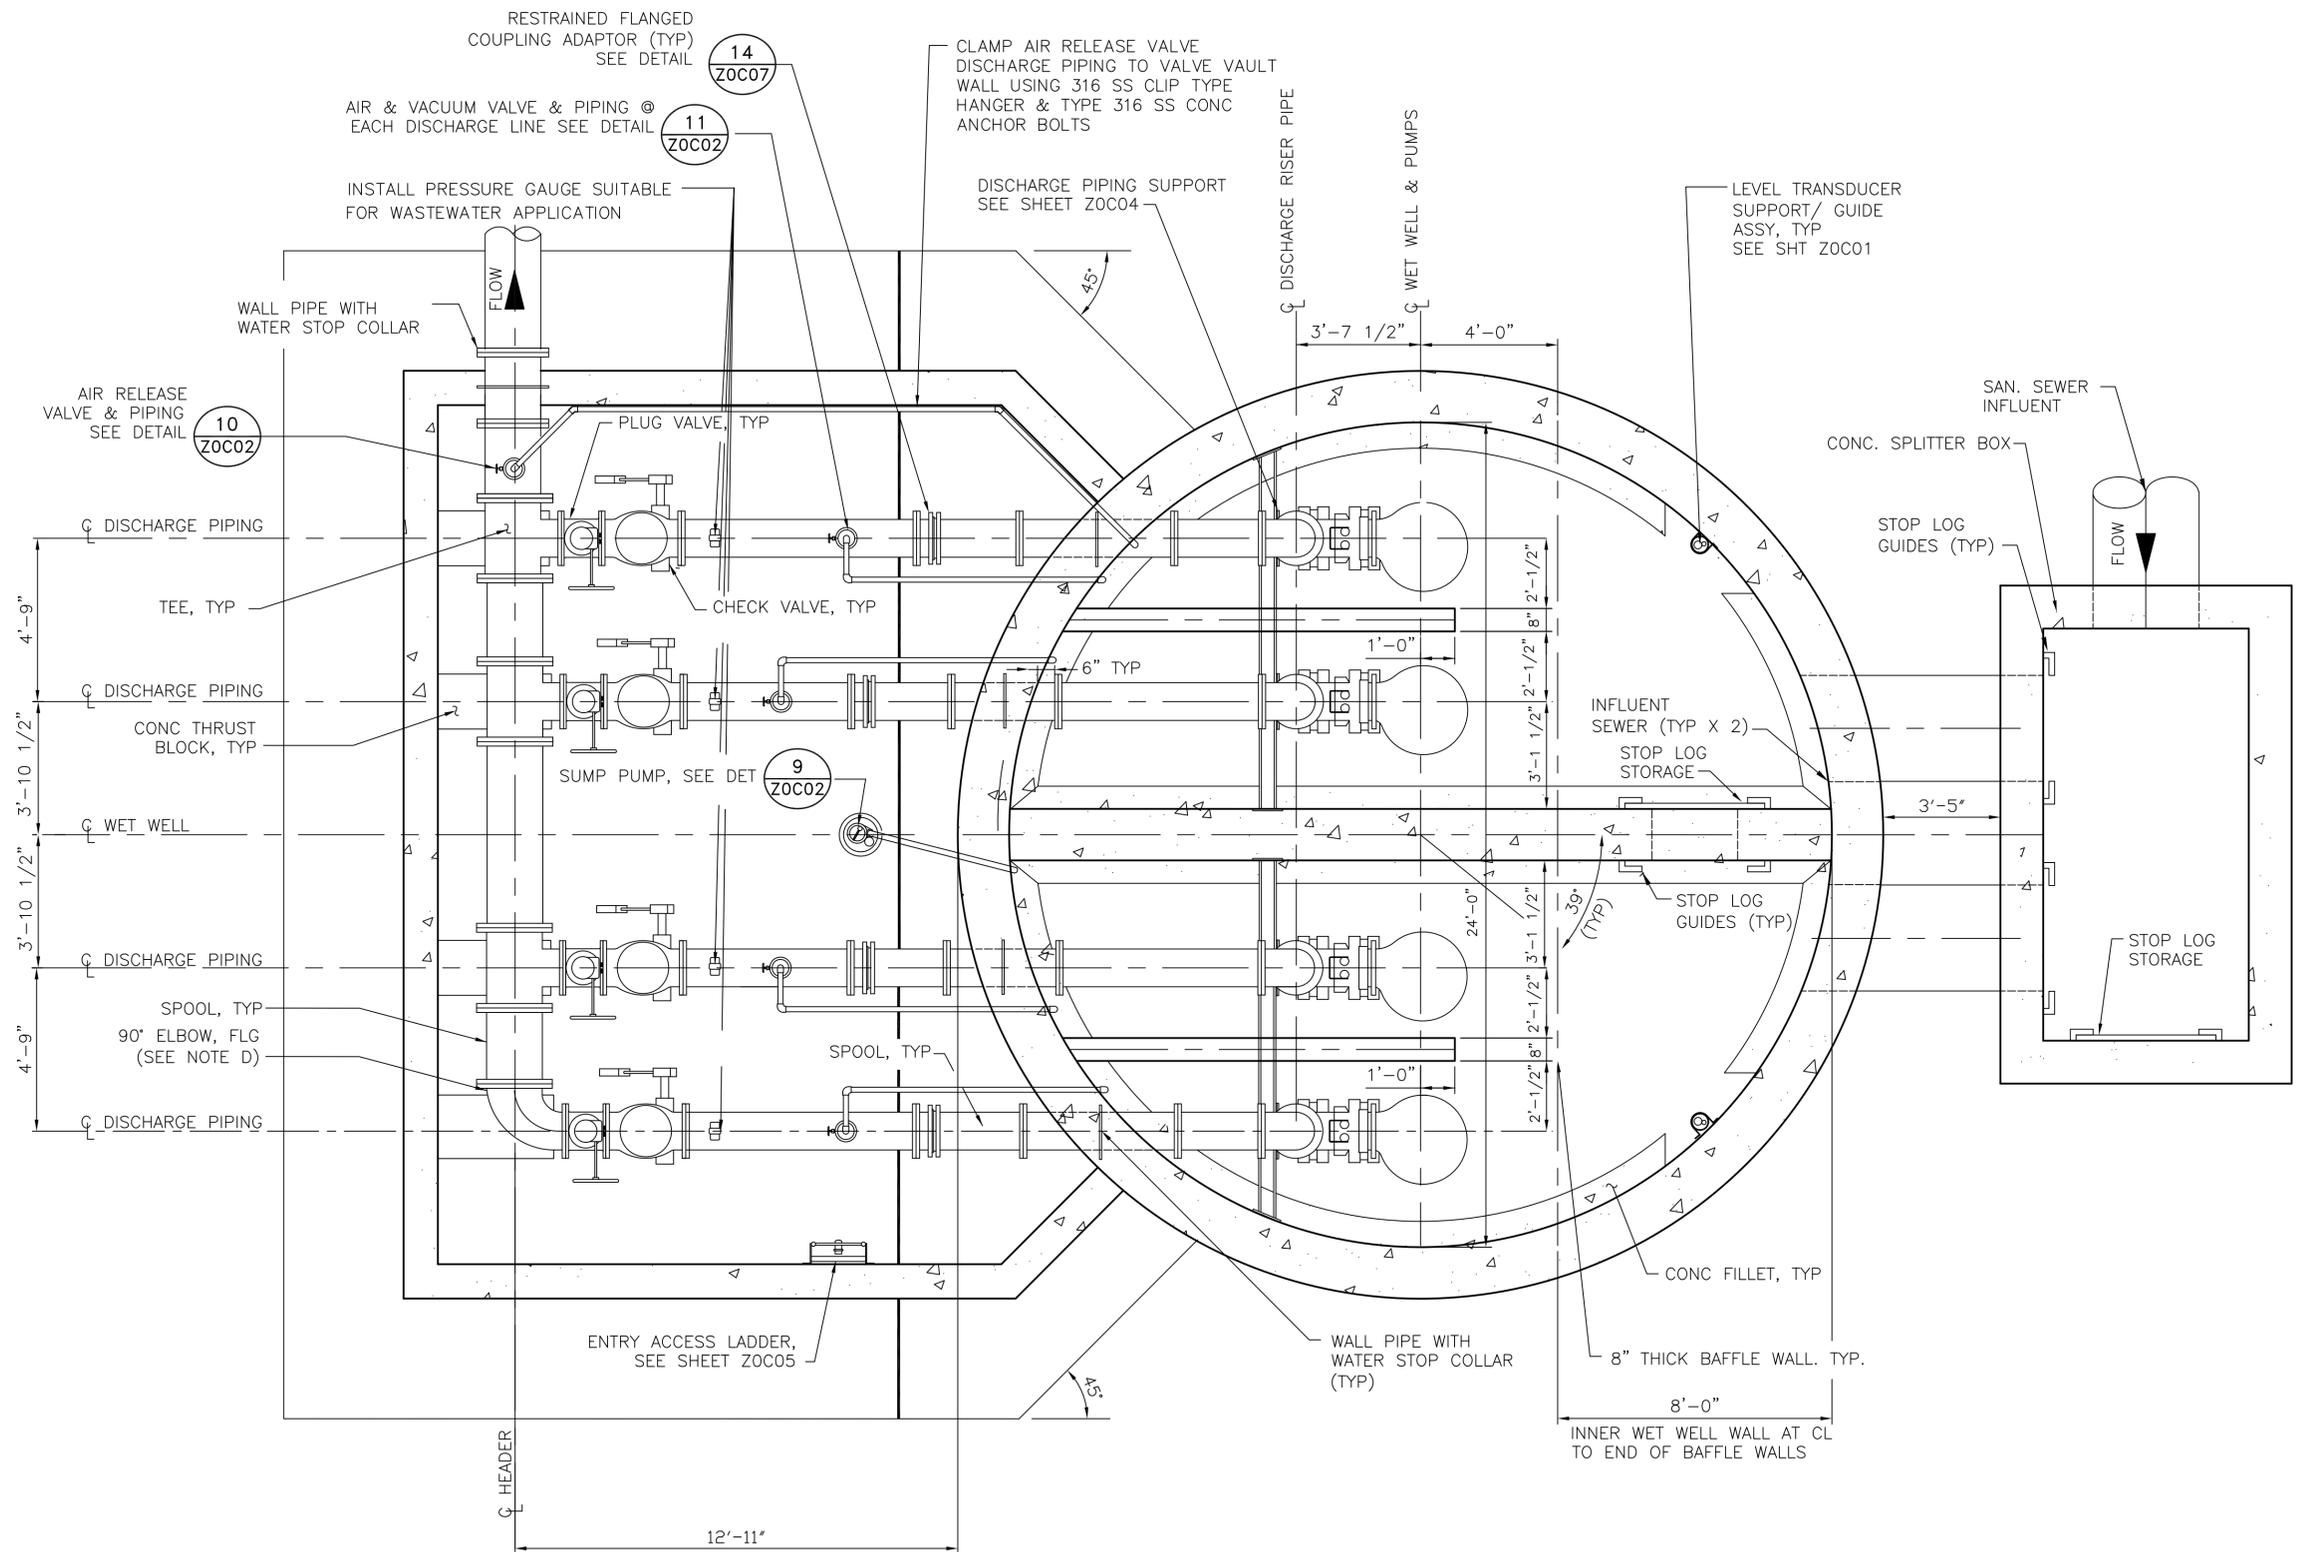

NOTES TO DESIGN ENGINEER:

A. THESE LIFT STATION DRAWINGS ARE CONSIDERED TO BE DESIGN GUIDELINES FOR THE CONSTRUCTION OF CITY OF HOUSTON WASTEWATER SUBMERSIBLE LIFT STATIONS. THEIR INTENDED USE IS AS A FRAMEWORK FOR THE CONTRACTED DESIGN ENGINEER IN DEVELOPING SPECIFIC LIFT STATION DESIGNS. IT IS THE RESPONSIBILITY OF THE CONTRACTED DESIGN ENGINEER TO VERIFY THE COMPLETENESS AND ACCURACY OF THE INFORMATION HEREIN CONTAINED AND TO ADJUST ACCORDING TO PROJECT SPECIFIC REQUIREMENTS.

B. THIS DESIGN IS BASED UPON THE LARGEST CAPACITY PUMP FOR THIS STANDARD (RANGE: 800 - 3499 GPM PER PUMP).

C. LIFT STATION DESIGN IS BASED UPON 10"-20" NOMINAL PUMP, VALVES AND PIPING AS THE SIZES RECOMMENDED FOR THIS STANDARD STATION. THE DESIGN WILL ACCOMMODATE VALVES AND PIPING IF PROJECT SPECIFIC CONDITIONS REQUIRE.

D. REPLACE THE 90° ELBOW WITH A FLANGED TEE FOR CONNECTION TO SURGE RELIEF VALVE, IF REQUIRED. SEE DETAILS, SHEET ZOC06.

E. DIMENSIONS NOTED ARE RELATIVE TO THE PUMP SIZE AND MANUFACTURER SELECTED. DESIGN ENGINEER SHALL VERIFY.

F. SEE DETAIL AND STRUCTURAL DRAWINGS FOR DIMENSIONS AND INFORMATION NOT SHOWN.

G. THE DESIGN ENGINEER SHALL INCORPORATE ONLY THE NECESSARY STANDARD GUIDELINE DRAWINGS AND DETAILS INTO HIS PROJECT CONTRACT DOCUMENTATION PACKAGE, AND SHALL ADJUST PAGE NUMBERS AND CROSS REFERENCING ACCORDINGLY.

H. THE DESIGN ENGINEER SHALL CONSULT THE CITY OF HOUSTON DESIGN GUIDELINES MANUAL, THE ENGINEERING DESIGN MANUAL, AND THE MASTER SPECIFICATIONS FOR FURTHER INSTRUCTIONS AND INFORMATION PERTINENT TO THESE STANDARD DESIGN GUIDELINE DRAWINGS.

I. THE DESIGN ENGINEER SHALL REMOVE THESE NOTES, ALL REFERENCES TO THESE NOTES, AND ANY OTHER EXTRANEOUS INFORMATION FROM THE DESIGN GUIDELINE DRAWINGS. DESIGN ENGINEER SHALL PROVIDE ANY NOTES OR OTHER APPROPRIATE INFORMATION NECESSARY TO COMPLETE THE LIFT STATION DESIGN.

- NOTES:**
- SEE DETAIL AND STRUCTURAL DRAWINGS FOR DIMENSIONS AND INFORMATION NOT SHOWN.
 - DIMENSIONS NOTED ARE RELATIVE TO THE PUMP SIZE AND MANUFACTURER SELECTED. CONTRACTOR SHALL CONFIRM.
 - INSTALL PLUG VALVES TO OPEN UPWARD AND TO CLOSE TO A SEATING POSITION.
 - INSTALL CHECK VALVES SO THAT THE WEIGHT LEVER POSITION IS APPROXIMATELY 45° BELOW THE VALVE HORIZONTAL CENTER LINE IN THE CLOSED POSITION; AND APPROXIMATELY 45° ABOVE THE VALVE HORIZONTAL CENTER LINE IN THE FULL OPEN POSITION.
 - SLEEVED OR CORED DISCHARGE PIPE OPENINGS SEALED WITH LINK-SEAL (OR APPROX. EQUAL) MAY BE SUBSTITUTED FOR POURED IN PLACE WALL PIPES TO ACCOMMODATE CONSTRUCTION METHOD.

BASE SECTION
 4 PUMPS @ 800 - 3499 GPM PER PUMP
 ALTERNATE LOW PROFILE CONFIGURATION

PROJECT NO. R-000267-0XXX-X

TITLE CITY OF HOUSTON
 DESIGN GUIDELINE DRAWINGS
 FOR SUBMERSIBLE LIFT STATIONS

CITY OF HOUSTON
 DEPARTMENT OF PUBLIC WORKS AND ENGINEERING
 ENGINEERING AND CONSTRUCTION



DESIGN ENGINEER TO INCLUDE COH STANDARD TITLE BLOCK ON ALL DRAWINGS, SEE STANDARD TITLE BLOCK DETAIL ON SHEET ZOC0X

SECTION B
 J3C02

| REV. NO. | DESCRIPTION | APP'D | DATE |
|----------|-------------|-------|------|
| | | | |
| | | | |
| | | | |
| | | | |

| | |
|--------------------|---------------------|
| SCALE: XX" = 1'-0" | DESIGNED BY: |
| SUBMITTED: | DRAWN BY: |
| DATE: MARCH, 2013 | SHEET NO. OF SHEETS |
| SURVEY BY: | DWG. NO. J3C03 |
| FIELD BOOK NO. | |

CADD DWG. FILE NO. : J3C03.DWG

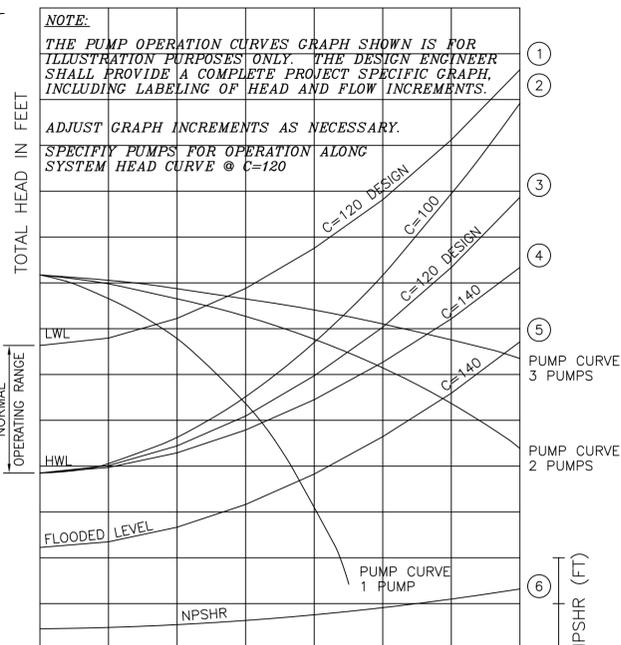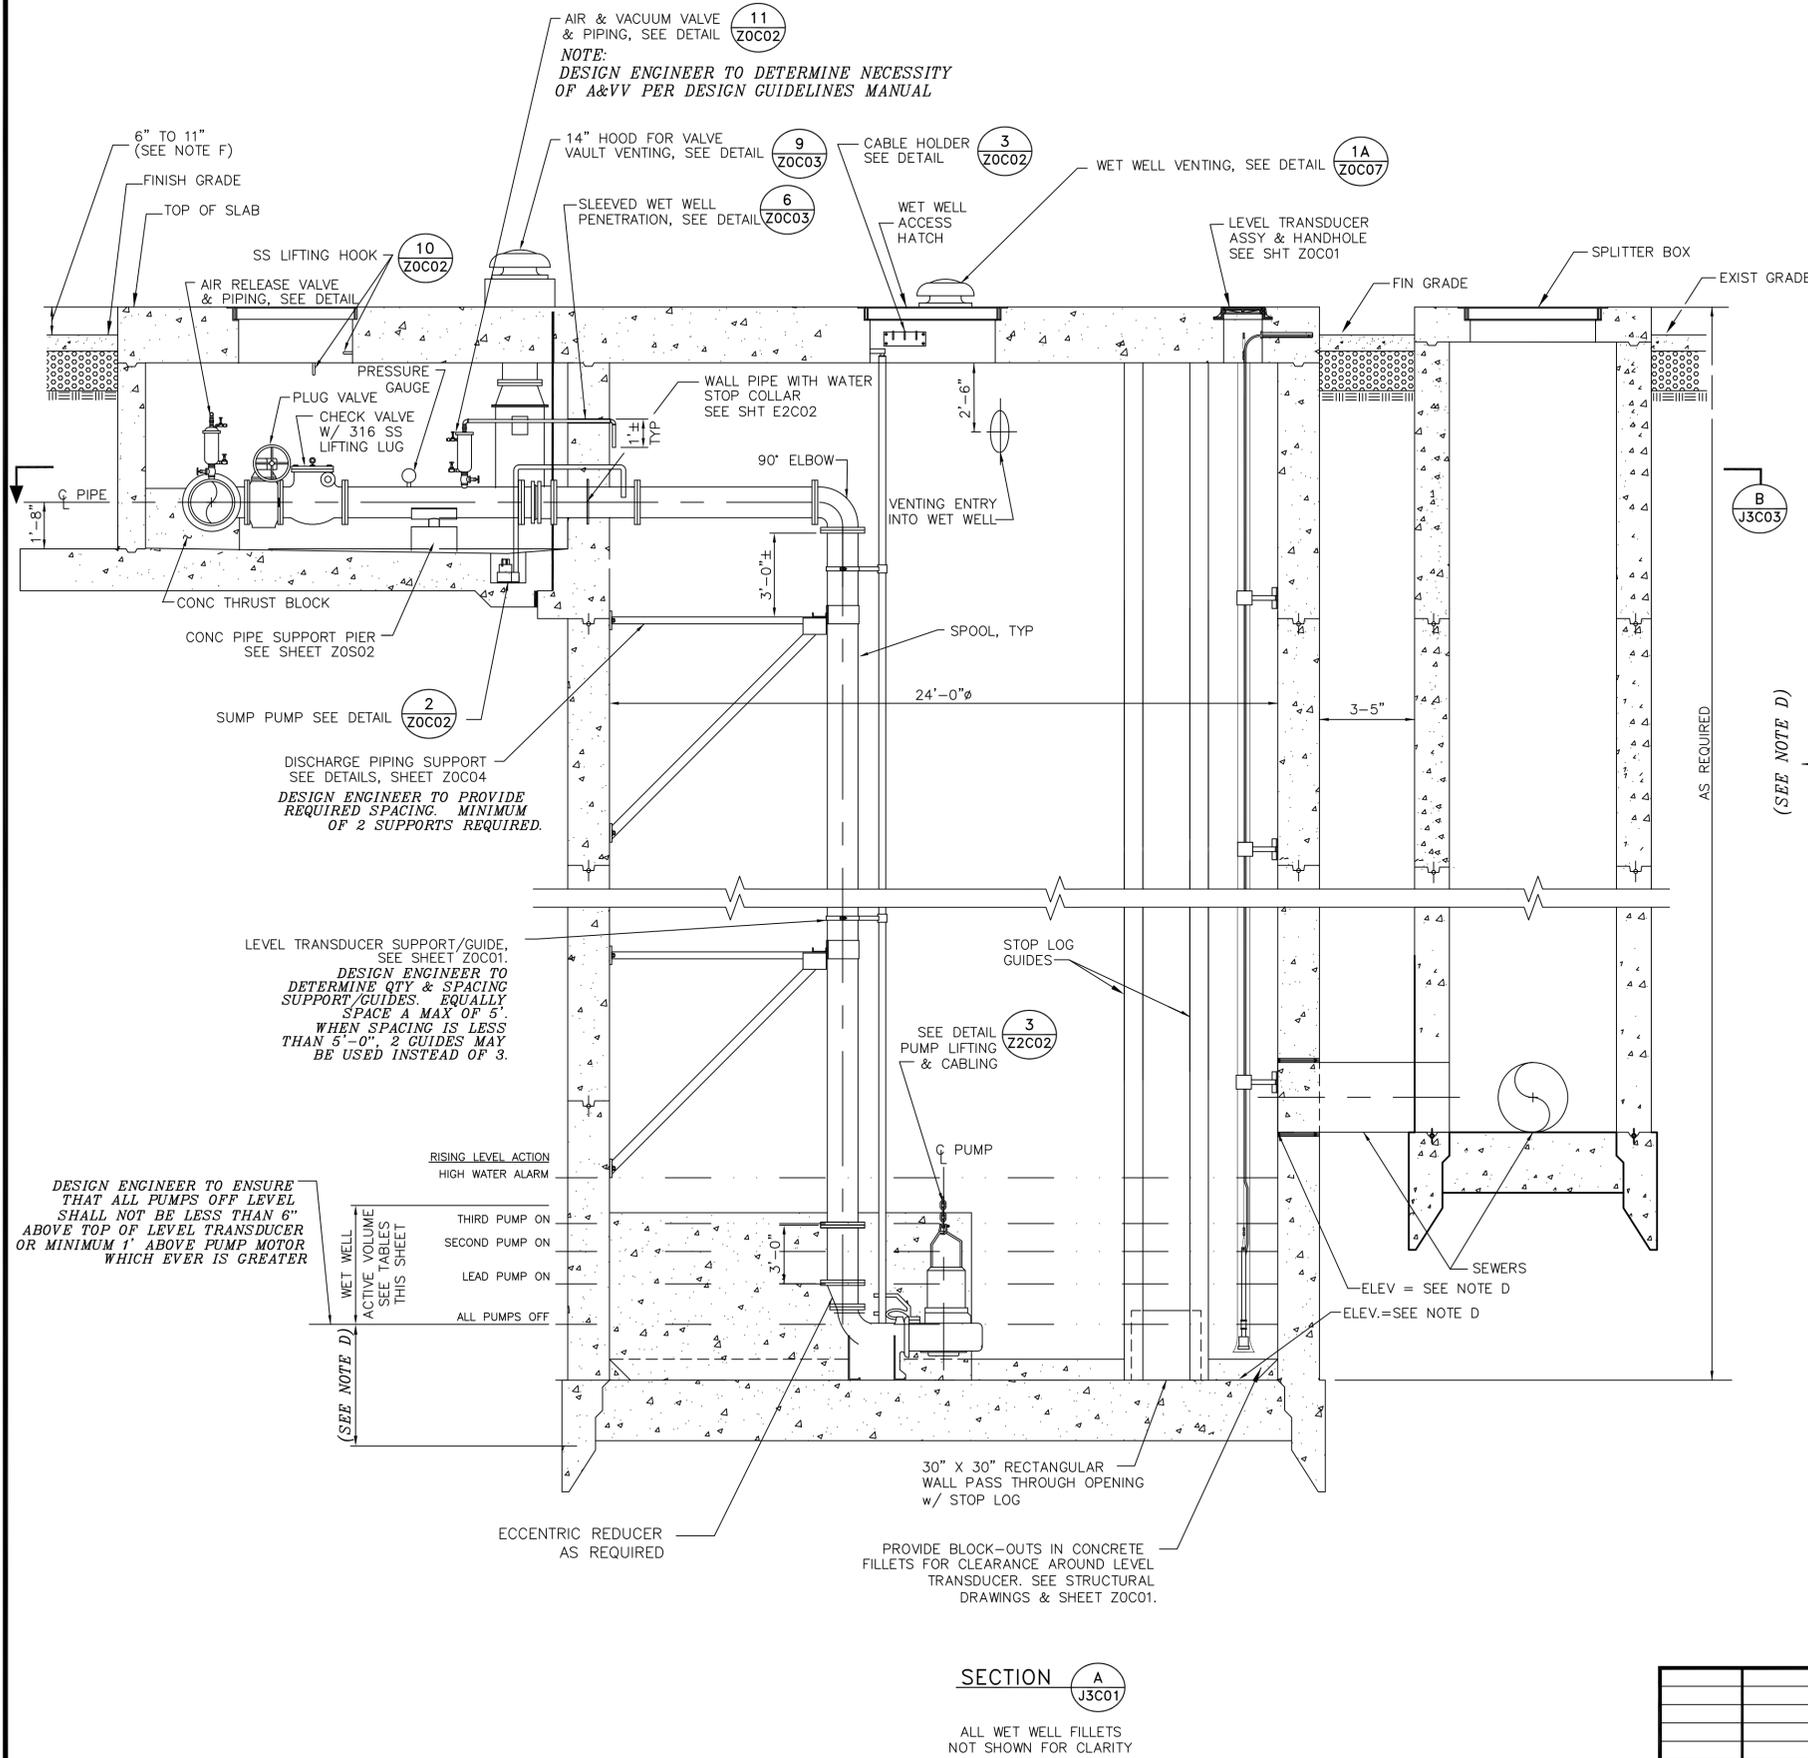

PUMP OPERATION CURVES

PUMP CURVE NOTES:

- LOW NORMAL OPERATING LEVEL C=120 - DESIGN.
- HIGH NORMAL OPERATING LEVEL C=100 - INFORMATION ONLY (TCEQ)
- HIGH NORMAL OPERATING LEVEL C=120 - DESIGN
- HIGH NORMAL OPERATING LEVEL C=140 - INFORMATION ONLY
- EMERGENCY FLOODED OPERATING LEVEL C=140 - MAXIMUM DISCHARGE
- NET POSITIVE SUCTION HEAD REQUIRED (NPSHR) BASED ON NORMAL OPERATING WATER LEVELS
- PUMP CURVES ARE MODIFIED FOR STATION LOSSES.

PUMP DATA TABLE

| PUMP CHARACTERISTICS | PUMP NO. 1 | PUMP NO. 2 | PUMP NO. 3 | PUMP NO. 4 |
|---|------------|------------|------------|------------|
| MOTOR DATA NOMINAL SIZE (HP) MAX SPEED (RPM) | | | | |
| SOLIDS PASSAGE MIN SPHERE (IN) | | | | |
| CAPACITY (GPM) DESIGN RUNOUT | | | | |
| DISCHARGE HEAD (FT) DESIGN RUNOUT SHUT OFF | | | | |
| EFFICIENCY (%) DESIGN | | | | |
| NPSHR (FT) DESIGN RUNOUT | | | | |
| PUMP CYCLE TIME | | | | |

STATION OPERATION TABLES

| RISING LEVEL CYCLE | | |
|-----------------------|-----------------------------|---|
| WATER LEVEL ELEVATION | ACTION | PUMP(S) IN OPERATION |
| | PUMPS OFF LEVEL - NO ACTION | ALL PUMPS ARE OFF |
| | LEAD PUMP TURNS ON | LEAD PUMP ON |
| | SECOND PUMP TURNS ON | LEAD & SECOND PUMPS ON |
| | THIRD PUMP TURNS ON | LEAD, SECOND & THIRD PUMPS ON |
| | HIGH WATER ALARM ON | HIGH WATER ALARM SOUND |
| FALLING LEVEL CYCLE | | |
| WATER LEVEL ELEVATION | ACTION | PUMP(S) IN OPERATION |
| | HIGH WATER LEVEL ALARM OFF | LEAD, SECOND & THIRD PUMPS ON |
| | LEAD PUMP TURNS OFF | SECOND & THIRD PUMPS ON |
| | SECOND PUMP TURNS OFF | THIRD PUMP ON |
| | THIRD PUMP TURNS OFF | ALL PUMPS STOPPED - STANDBY PUMP SWITCHES TO LEAD PUMP |

NOTES TO DESIGN ENGINEER:

- THESE LIFT STATION DRAWINGS ARE CONSIDERED TO BE DESIGN GUIDELINES FOR THE CONSTRUCTION OF CITY OF HOUSTON WASTEWATER SUBMERSIBLE LIFT STATIONS. THEIR INTENDED USE IS AS A FRAMEWORK FOR THE CONTRACTED DESIGN ENGINEER IN DEVELOPING SPECIFIC LIFT STATION DESIGNS. IT IS THE RESPONSIBILITY OF THE CONTRACTED DESIGN ENGINEER TO VERIFY THE COMPLETENESS AND ACCURACY OF THE INFORMATION HEREIN CONTAINED AND TO ADJUST ACCORDING TO PROJECT SPECIFIC REQUIREMENTS.
- THIS DESIGN IS BASED UPON THE LARGEST CAPACITY PUMP FOR THIS STANDARD (RANGE: 800 - 3499 GPM PER PUMP).
- LIFT STATION DESIGN IS BASED UPON 10"-20" NOMINAL PUMP, VALVES AND PIPING AS THE SIZES RECOMMENDED FOR THIS STANDARD STATION. THE DESIGN WILL ACCOMMODATE VALVES AND PIPING IF PROJECT SPECIFIC CONDITIONS REQUIRE.
- ELEVATIONS AND INFORMATION OMITTED ARE DETERMINED BY DESIGN ENGINEER FOR PROJECT SPECIFIC REQUIREMENTS.
- DIMENSIONS NOTED ARE RELATIVE TO THE PUMP SIZE AND MANUFACTURER SELECTED. DESIGN ENGINEER SHALL VERIFY DESIGN ENGINEER SHALL PROVIDE RAISED PUMP BASE IF REQUIRED.
- WHERE FLOOD PLAIN CONDITIONS REQUIRE THE TOP SLAB TO BE GREATER THAN 1'-0" ABOVE FINISHED GRADE, DESIGN ENGINEER SHALL PROVIDE CONCRETE STAIRS.
- SEE DETAIL AND STRUCTURAL DRAWINGS FOR DIMENSIONS AND INFORMATION NOT SHOWN.
- THE DESIGN ENGINEER SHALL INCORPORATE ONLY THE NECESSARY STANDARD GUIDELINE DRAWINGS AND DETAILS INTO HIS PROJECT CONTRACT DOCUMENTATION PACKAGE, AND SHALL ADJUST PAGE NUMBERS AND CROSS REFERENCING ACCORDINGLY.
- THE DESIGN ENGINEER SHALL CONSULT THE CITY OF HOUSTON DESIGN GUIDELINES MANUAL, THE ENGINEERING DESIGN MANUAL, AND THE MASTER SPECIFICATIONS FOR FURTHER INSTRUCTIONS AND INFORMATION PERTINENT TO THESE STANDARD DESIGN GUIDELINE DRAWINGS.
- THE DESIGN ENGINEER SHALL REMOVE THESE NOTES, ALL REFERENCES TO THESE NOTES, AND ANY OTHER EXTRANEOUS INFORMATION FROM THE DESIGN GUIDELINE DRAWINGS. DESIGN ENGINEER SHALL PROVIDE ANY NOTES OR OTHER APPROPRIATE INFORMATION NECESSARY TO COMPLETE THE LIFT STATION DESIGN.

NOTES:

- DIMENSIONS NOTED ARE RELATIVE TO THE PUMP SIZE AND MANUFACTURER SELECTED. CONTRACTOR SHALL CONFIRM.
- SEE DETAIL AND STRUCTURAL DRAWINGS FOR DIMENSIONS AND INFORMATION NOT SHOWN.
- PUMP ANCHOR BOLTS ARE TO BE ADHESIVE TYPE, AND EMBEDDED IN CONCRETE SLAB. CONTRACTOR TO SUBMIT DESIGN OF PUMP ANCHOR BOLTS AND PATTERN, INCLUDING CALCULATIONS, DURING SHOP DRAWING SUBMISSION.
- CONTRACTOR TO PROVIDE ADHESIVE ANCHORS IN LIEU OF WEDGE ANCHORS FOR ALL SUBMERGED CONDITIONS, AND SUBMIT DESIGN OF ANCHOR BOLTS DURING SHOP DRAWING SUBMISSION.
- ALL PIPING IN THE WET WELL SHALL BE FLANGED. NO FLANGED COUPLING ADAPTORS, OR VICTAULIC STYLE COUPLINGS SHALL BE PERMITTED INSIDE THE WET WELL.

ELEVATION SECTION
 4 PUMPS @800 - 3499 GPM PER PUMP
 ALTERNATE LOW PROFILE CONFIGURATION

PROJECT NO. R-000267-0XXX-X

TITLE CITY OF HOUSTON
 DESIGN GUIDELINE DRAWINGS
 FOR SUBMERSIBLE LIFT STATIONS

CITY OF HOUSTON
 DEPARTMENT OF PUBLIC WORKS AND ENGINEERING
 ENGINEERING AND CONSTRUCTION

 
DESIGN ENGINEER TO INCLUDE COH STANDARD TITLE BLOCK ON ALL DRAWINGS, SEE STANDARD TITLE BLOCK DETAIL ON SHEET ZOC0X

SCALE: XX" = 1'-0" DESIGNED BY:
 SUBMITTED: DRAWN BY:
 DATE: MARCH, 2013 SHEET NO. OF SHEETS
 SURVEY BY: DWG. NO.
 FIELD BOOK NO. J3C02

SECTION A
 J3C01

ALL WET WELL FILLETS NOT SHOWN FOR CLARITY

CADD DWG. FILE NO. : J3C02.DWG




DESIGN ENGINEER SHALL ORIENT NORTH
ARROW ACCORDING TO SPECIFIC SITE PLAN

NOTES TO DESIGN ENGINEER:

- A. THESE LIFT STATION DRAWINGS ARE CONSIDERED TO BE DESIGN GUIDELINES FOR THE CONSTRUCTION OF CITY OF HOUSTON WASTEWATER SUBMERSIBLE LIFT STATIONS. THEIR INTENDED USE IS AS A FRAMEWORK FOR THE CONTRACTED DESIGN ENGINEER IN DEVELOPING SPECIFIC LIFT STATION DESIGNS. IT IS THE RESPONSIBILITY OF THE CONTRACTED DESIGN ENGINEER TO VERIFY THE COMPLETENESS AND ACCURACY OF THE INFORMATION HEREIN CONTAINED AND TO ADJUST ACCORDING TO PROJECT SPECIFIC REQUIREMENTS.
- B. THIS DESIGN IS BASED UPON THE LARGEST CAPACITY PUMP FOR THIS STANDARD (RANGE: 800 - 3499 GPM PER PUMP).
- C. LIFT STATION DESIGN IS BASED UPON 10"-20" NOMINAL PUMP, VALVES AND PIPING AS THE SIZES RECOMMENDED FOR THIS STANDARD STATION. THE DESIGN WILL ACCOMMODATE VALVES AND PIPING IF PROJECT SPECIFIC CONDITIONS REQUIRE.
- D. DESIGN ENGINEER TO VERIFY THE SIZE AND LOCATION OF THE WET WELL HATCHES ACCORDING TO THE SELECTED HATCH AND PUMP MANUFACTURERS' REQUIREMENTS.
- E. THE ACTUAL LOCATION OF THE WET WELL VENTING MAY VARY ACCORDING TO SITE REQUIREMENTS. WHERE POSSIBLE, LOCATE ON THE NORTHWEST SIDE OF THE WET WELL.
- F. SEE DETAIL AND STRUCTURAL DRAWINGS FOR DIMENSIONS AND INFORMATION NOT SHOWN.
- G. THE DESIGN ENGINEER SHALL INCORPORATE ONLY THE NECESSARY STANDARD GUIDELINE DRAWINGS AND DETAILS INTO HIS PROJECT CONTRACT DOCUMENTATION PACKAGE, AND SHALL ADJUST PAGE NUMBERS AND CROSS REFERENCING ACCORDINGLY.
- H. THE DESIGN ENGINEER SHALL CONSULT THE CITY OF HOUSTON DESIGN GUIDELINES MANUAL, THE ENGINEERING DESIGN MANUAL, AND THE MASTER SPECIFICATIONS FOR FURTHER INSTRUCTIONS AND INFORMATION PERTINENT TO THESE STANDARD DESIGN GUIDELINE DRAWINGS.
- I. THE DESIGN ENGINEER SHALL REMOVE THESE NOTES, ALL REFERENCES TO THESE NOTES, AND ANY OTHER EXTRANEOUS INFORMATION FROM THE DESIGN GUIDELINE DRAWINGS. DESIGN ENGINEER SHALL PROVIDE ANY NOTES OR OTHER APPROPRIATE INFORMATION NECESSARY TO COMPLETE THE LIFT STATION DESIGN.

NOTES:

- 1. SEE DETAIL AND STRUCTURAL DRAWINGS FOR DIMENSIONS AND INFORMATION NOT SHOWN.
- 2. CONTRACTOR TO CONFIRM SIZE AND LOCATION OF THE WET WELL HATCHES PER SELECTED HATCH AND PUMP MANUFACTURERS' REQUIREMENTS.

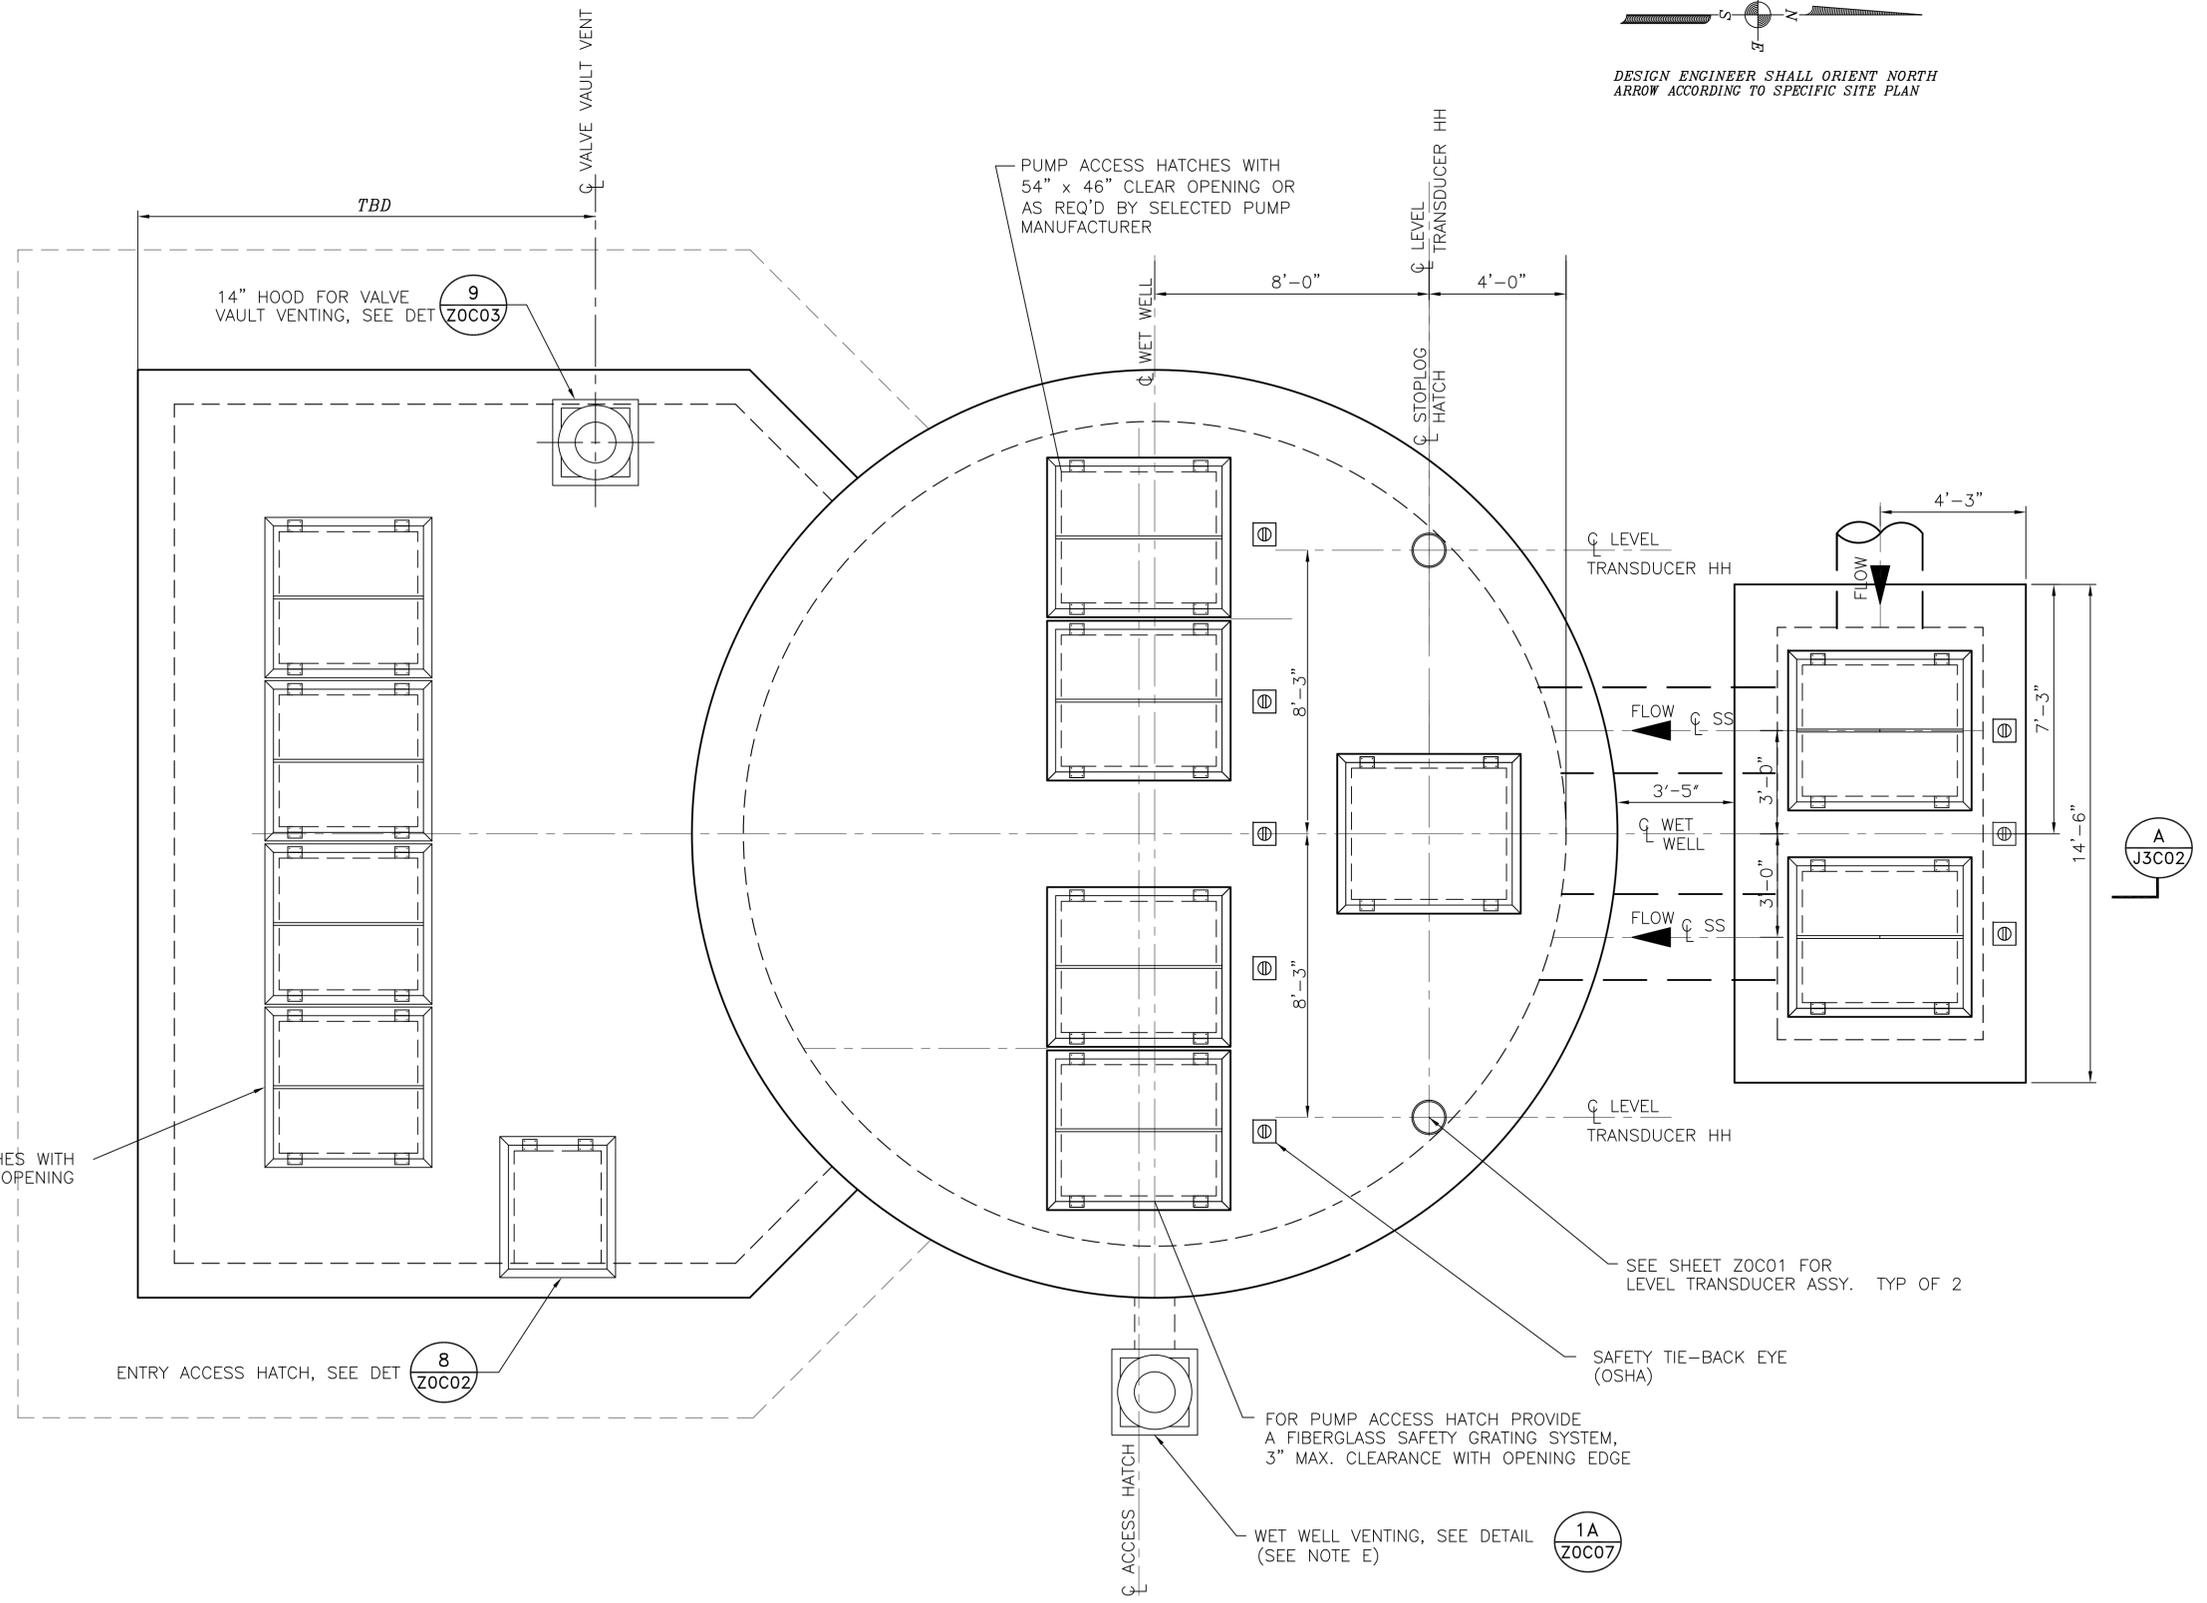

PLAN VIEW @ GRADE
4 PUMPS @ 800 - 3499 GPM PER PUMP
ALTERNATE LOW PROFILE CONFIGURATION

PROJECT NO. R-000267-0XXX-X

TITLE CITY OF HOUSTON
DESIGN GUIDELINE DRAWINGS
FOR SUBMERSIBLE LIFT STATIONS


CITY OF HOUSTON
DEPARTMENT OF PUBLIC WORKS AND ENGINEERING
ENGINEERING AND CONSTRUCTION

DESIGN ENGINEER TO INCLUDE COH STANDARD TITLE BLOCK ON ALL DRAWINGS, SEE STANDARD TITLE BLOCK DETAIL ON SHEET ZOC0X





| | |
|--------------------|---------------------|
| SCALE: xx" = 1'-0" | DESIGNED BY: |
| SUBMITTED: | DRAWN BY: |
| DATE: MARCH, 2013 | SHEET NO. OF SHEETS |
| SURVEY BY: | DWG. NO. J3C01 |
| FIELD BOOK NO. | |

| REV. NO. | DESCRIPTION | APP'D | DATE |
|----------|-------------|-------|------|
| | | | |
| | | | |
| | | | |
| | | | |

 CADD DWG. FILE NO. : J3C01.DWG



ORIGINAL SCALE IN INCHES FOR REDUCED PLANS
DESIGN ENGINEER TO UPDATE BAR SCALE TO REFLECT ACTUAL SCALE ON THE DRAWING.

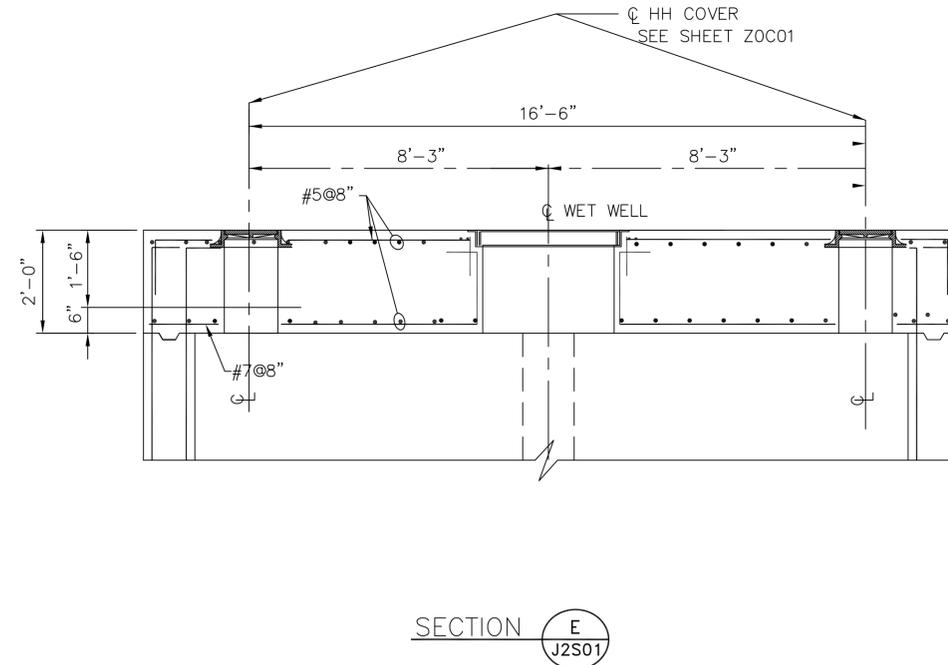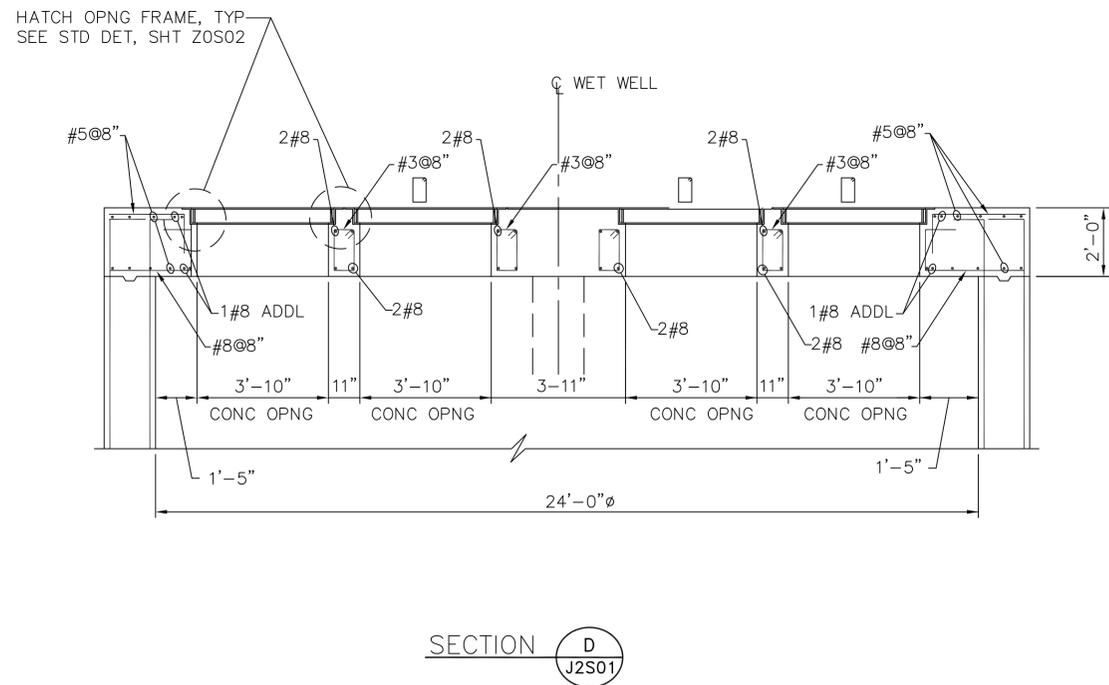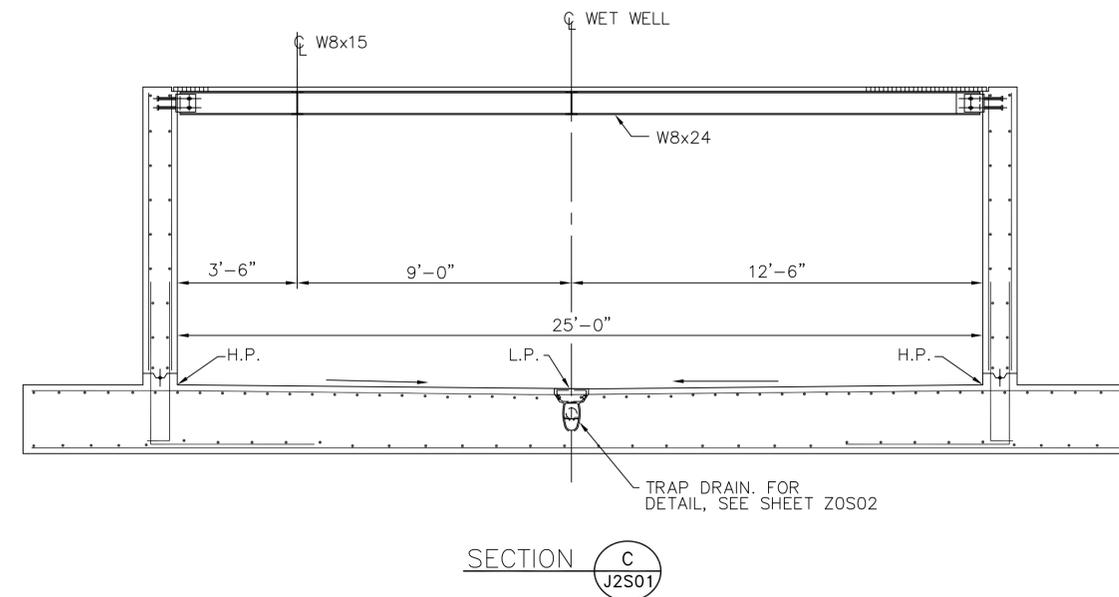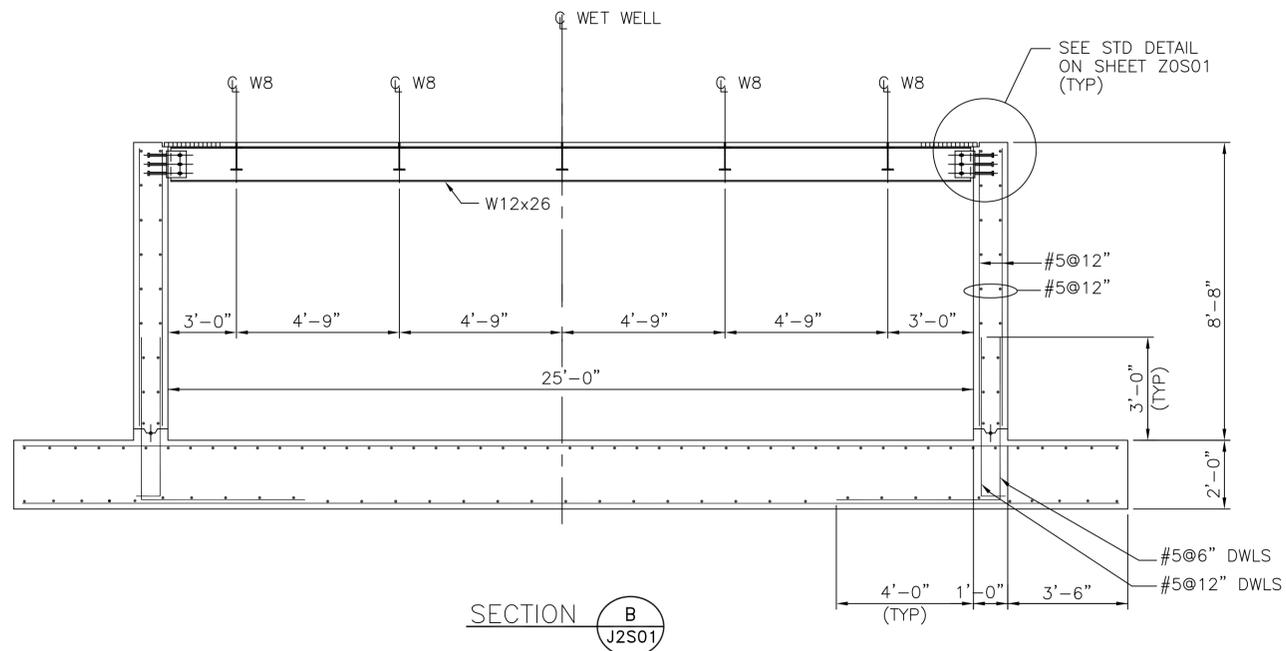

NOTES TO DESIGN ENGINEER:

- A. THESE LIFT STATION DRAWINGS ARE CONSIDERED TO BE DESIGN GUIDELINES FOR THE CONSTRUCTION OF CITY OF HOUSTON WASTEWATER SUBMERSIBLE LIFT STATIONS. THEIR INTENDED USE IS AS A FRAMEWORK FOR THE CONTRACTED DESIGN ENGINEER IN DEVELOPING SPECIFIC LIFT STATION DESIGNS. IT IS THE RESPONSIBILITY OF THE CONTRACTED DESIGN ENGINEER TO VERIFY THE COMPLETENESS AND ACCURACY OF THE INFORMATION HEREIN CONTAINED AND TO ADJUST ACCORDING TO PROJECT SPECIFIC REQUIREMENTS.
- B. DESIGN ENGINEER TO VERIFY SIZE AND LOCATION OF THE ACCESS HATCH OPENINGS PER SELECTED HATCH AND PUMP MANUFACTURERS' REQUIREMENTS.
- C. SEE DETAIL AND CIVIL DRAWINGS FOR DIMENSIONS AND INFORMATION NOT SHOWN.
- D. THE DESIGN ENGINEER SHALL INCORPORATE ONLY THE NECESSARY STANDARD GUIDELINE DRAWINGS AND DETAILS INTO HIS PROJECT CONTRACT DOCUMENTATION PACKAGE, AND SHALL ADJUST PAGE NUMBERS AND CROSS REFERENCING ACCORDINGLY.
- E. THE DESIGN ENGINEER SHALL CONSULT THE CITY OF HOUSTON DESIGN GUIDELINES MANUAL, THE ENGINEERING DESIGN MANUAL, AND THE MASTER SPECIFICATIONS FOR FURTHER INSTRUCTIONS AND INFORMATION PERTINENT TO THESE STANDARD DESIGN GUIDELINE DRAWINGS.
- F. THE DESIGN ENGINEER SHALL REMOVE THESE NOTES, ALL REFERENCES TO THESE NOTES, AND ANY OTHER EXTRANEOUS INFORMATION FROM THE DESIGN GUIDELINE DRAWINGS. DESIGN ENGINEER SHALL PROVIDE ANY NOTES OR OTHER APPROPRIATE INFORMATION NECESSARY TO COMPLETE THE LIFT STATION DESIGN.

- NOTES:**
- 1. FOR ADDITIONAL REINFORCEMENT AT OPENINGS NOT SHOWN, SEE SHEET ZOS01.
 - 2. CONTRACTOR TO CONFIRM THE SIZE AND LOCATION OF THE ACCESS HATCH OPENINGS PER SELECTED HATCH AND PUMP MANUFACTURERS' REQUIREMENTS.
 - 3. SEE DETAIL AND CIVIL DRAWINGS FOR DIMENSIONS AND INFORMATION NOT SHOWN.

STRUCTURAL
4 PUMPS @ 800 -3499 GPM PER PUMP
PREFERRED CONFIGURATION

PROJECT NO. R-000267-0XXX-X
 TITLE CITY OF HOUSTON
 DESIGN GUIDELINE DRAWINGS
 FOR SUBMERSIBLE LIFT STATIONS
CITY OF HOUSTON
 DEPARTMENT OF PUBLIC WORKS AND ENGINEERING
 ENGINEERING AND CONSTRUCTION

DESIGN ENGINEER TO INCLUDE COH STANDARD TITLE BLOCK ON ALL DRAWINGS, SEE STANDARD TITLE BLOCK DETAIL ON SHEET ZOC0X

CADD DWG. FILE NO. : J2S04.DWG

| REV. NO. | DESCRIPTION | APP'D | DATE |
|----------|-------------|-------|------|
| | | | |
| | | | |
SCALE: XX" = 1'-0" DESIGNED BY:
 SUBMITTED: DRAWN BY:
 DATE: MARCH, 2013 SHEET NO. OF SHEETS
 SURVEY BY: DWG. NO. J2S04
 FIELD BOOK NO.

NOTES TO DESIGN ENGINEER:


- A. THESE LIFT STATION DRAWINGS ARE CONSIDERED TO BE DESIGN GUIDELINES FOR THE CONSTRUCTION OF CITY OF HOUSTON WASTEWATER SUBMERSIBLE LIFT STATIONS. THEIR INTENDED USE IS AS A FRAMEWORK FOR THE CONTRACTED DESIGN ENGINEER IN DEVELOPING SPECIFIC LIFT STATION DESIGNS. IT IS THE RESPONSIBILITY OF THE CONTRACTED DESIGN ENGINEER TO VERIFY THE COMPLETENESS AND ACCURACY OF THE INFORMATION HEREIN CONTAINED AND TO ADJUST ACCORDING TO PROJECT SPECIFIC REQUIREMENTS.
- B. DESIGN ENGINEER TO VERIFY SIZE AND LOCATION OF THE ACCESS HATCH OPENINGS PER SELECTED HATCH AND PUMP MANUFACTURERS' REQUIREMENTS.
- C. DIMENSIONS, ELEVATIONS AND REINFORCING NOT PROVIDED ARE TO BE DETERMINED BY THE DESIGN ENGINEER PER APPLICABLE SITE REQUIREMENTS.
- D. SEE DETAIL AND CIVIL DRAWINGS FOR DIMENSIONS AND INFORMATION NOT SHOWN.
- E. DESIGN ENGINEER TO PROVIDE WET WELL DESIGN FOR EITHER OPEN-CUT OR CAISSON CONSTRUCTION.
- F. THE DESIGN ENGINEER SHALL INCORPORATE ONLY THE NECESSARY STANDARD GUIDELINE DRAWINGS AND DETAILS INTO HIS PROJECT CONTRACT DOCUMENTATION PACKAGE, AND SHALL ADJUST PAGE NUMBERS AND CROSS REFERENCING ACCORDINGLY.
- G. THE DESIGN ENGINEER SHALL CONSULT THE CITY OF HOUSTON DESIGN GUIDELINES MANUAL, THE ENGINEERING DESIGN MANUAL, AND THE MASTER SPECIFICATIONS FOR FURTHER INSTRUCTIONS AND INFORMATION PERTINENT TO THESE STANDARD DESIGN GUIDELINE DRAWINGS.
- H. THE DESIGN ENGINEER SHALL REMOVE THESE NOTES, ALL REFERENCES TO THESE NOTES, AND ANY OTHER EXTRANEOUS INFORMATION FROM THE DESIGN GUIDELINE DRAWINGS. DESIGN ENGINEER SHALL PROVIDE ANY NOTES OR OTHER APPROPRIATE INFORMATION NECESSARY TO COMPLETE THE LIFT STATION DESIGN.

NOTES:

- 1. FOR ADDITIONAL REINFORCEMENT AT OPENINGS NOT SHOWN, SEE SHEET ZOS01.
- 2. CONTRACTOR TO CONFIRM SIZE AND LOCATION OF THE ACCESS HATCH OPENINGS PER SELECTED HATCH AND PUMP MANUFACTURERS' REQUIREMENTS.
- 3. DIMENSIONS NOTED ARE RELATIVE TO THE PUMP SIZE AND MANUFACTURER SELECTED. CONTRACTOR SHALL CONFIRM.
- 4. SEE DETAIL AND CIVIL DRAWINGS FOR DIMENSIONS AND INFORMATION NOT SHOWN.
- 5. WET WELL TO BE LINED WITH CONCRETE PROTECTIVE LINER PER PROJECT SPECIFICATIONS, CONSULT WITH COH PROJECT MANAGER FOR APPROVED PRODUCTS. LINER SHALL COVER ALL CONCRETE SURFACES, AND SHALL EXTEND TO A MINIMUM OF 12" BELOW THE LOW WATER ELEVATION.

| | |
|--|---|
| STRUCTURAL | |
| 4 PUMPS @ 800 -3499 GPM PER PUMP PREFERRED CONFIGURATION | |
| PROJECT NO. | R-000267-0XXX-X |
| TITLE | CITY OF HOUSTON DESIGN GUIDELINE DRAWINGS FOR SUBMERSIBLE LIFT STATIONS |
| CITY OF HOUSTON | |
| DEPARTMENT OF PUBLIC WORKS AND ENGINEERING ENGINEERING AND CONSTRUCTION | |


DESIGN ENGINEER TO INCLUDE COH STANDARD TITLE BLOCK ON ALL DRAWINGS, SEE STANDARD TITLE BLOCK DETAIL ON SHEET ZOC0X

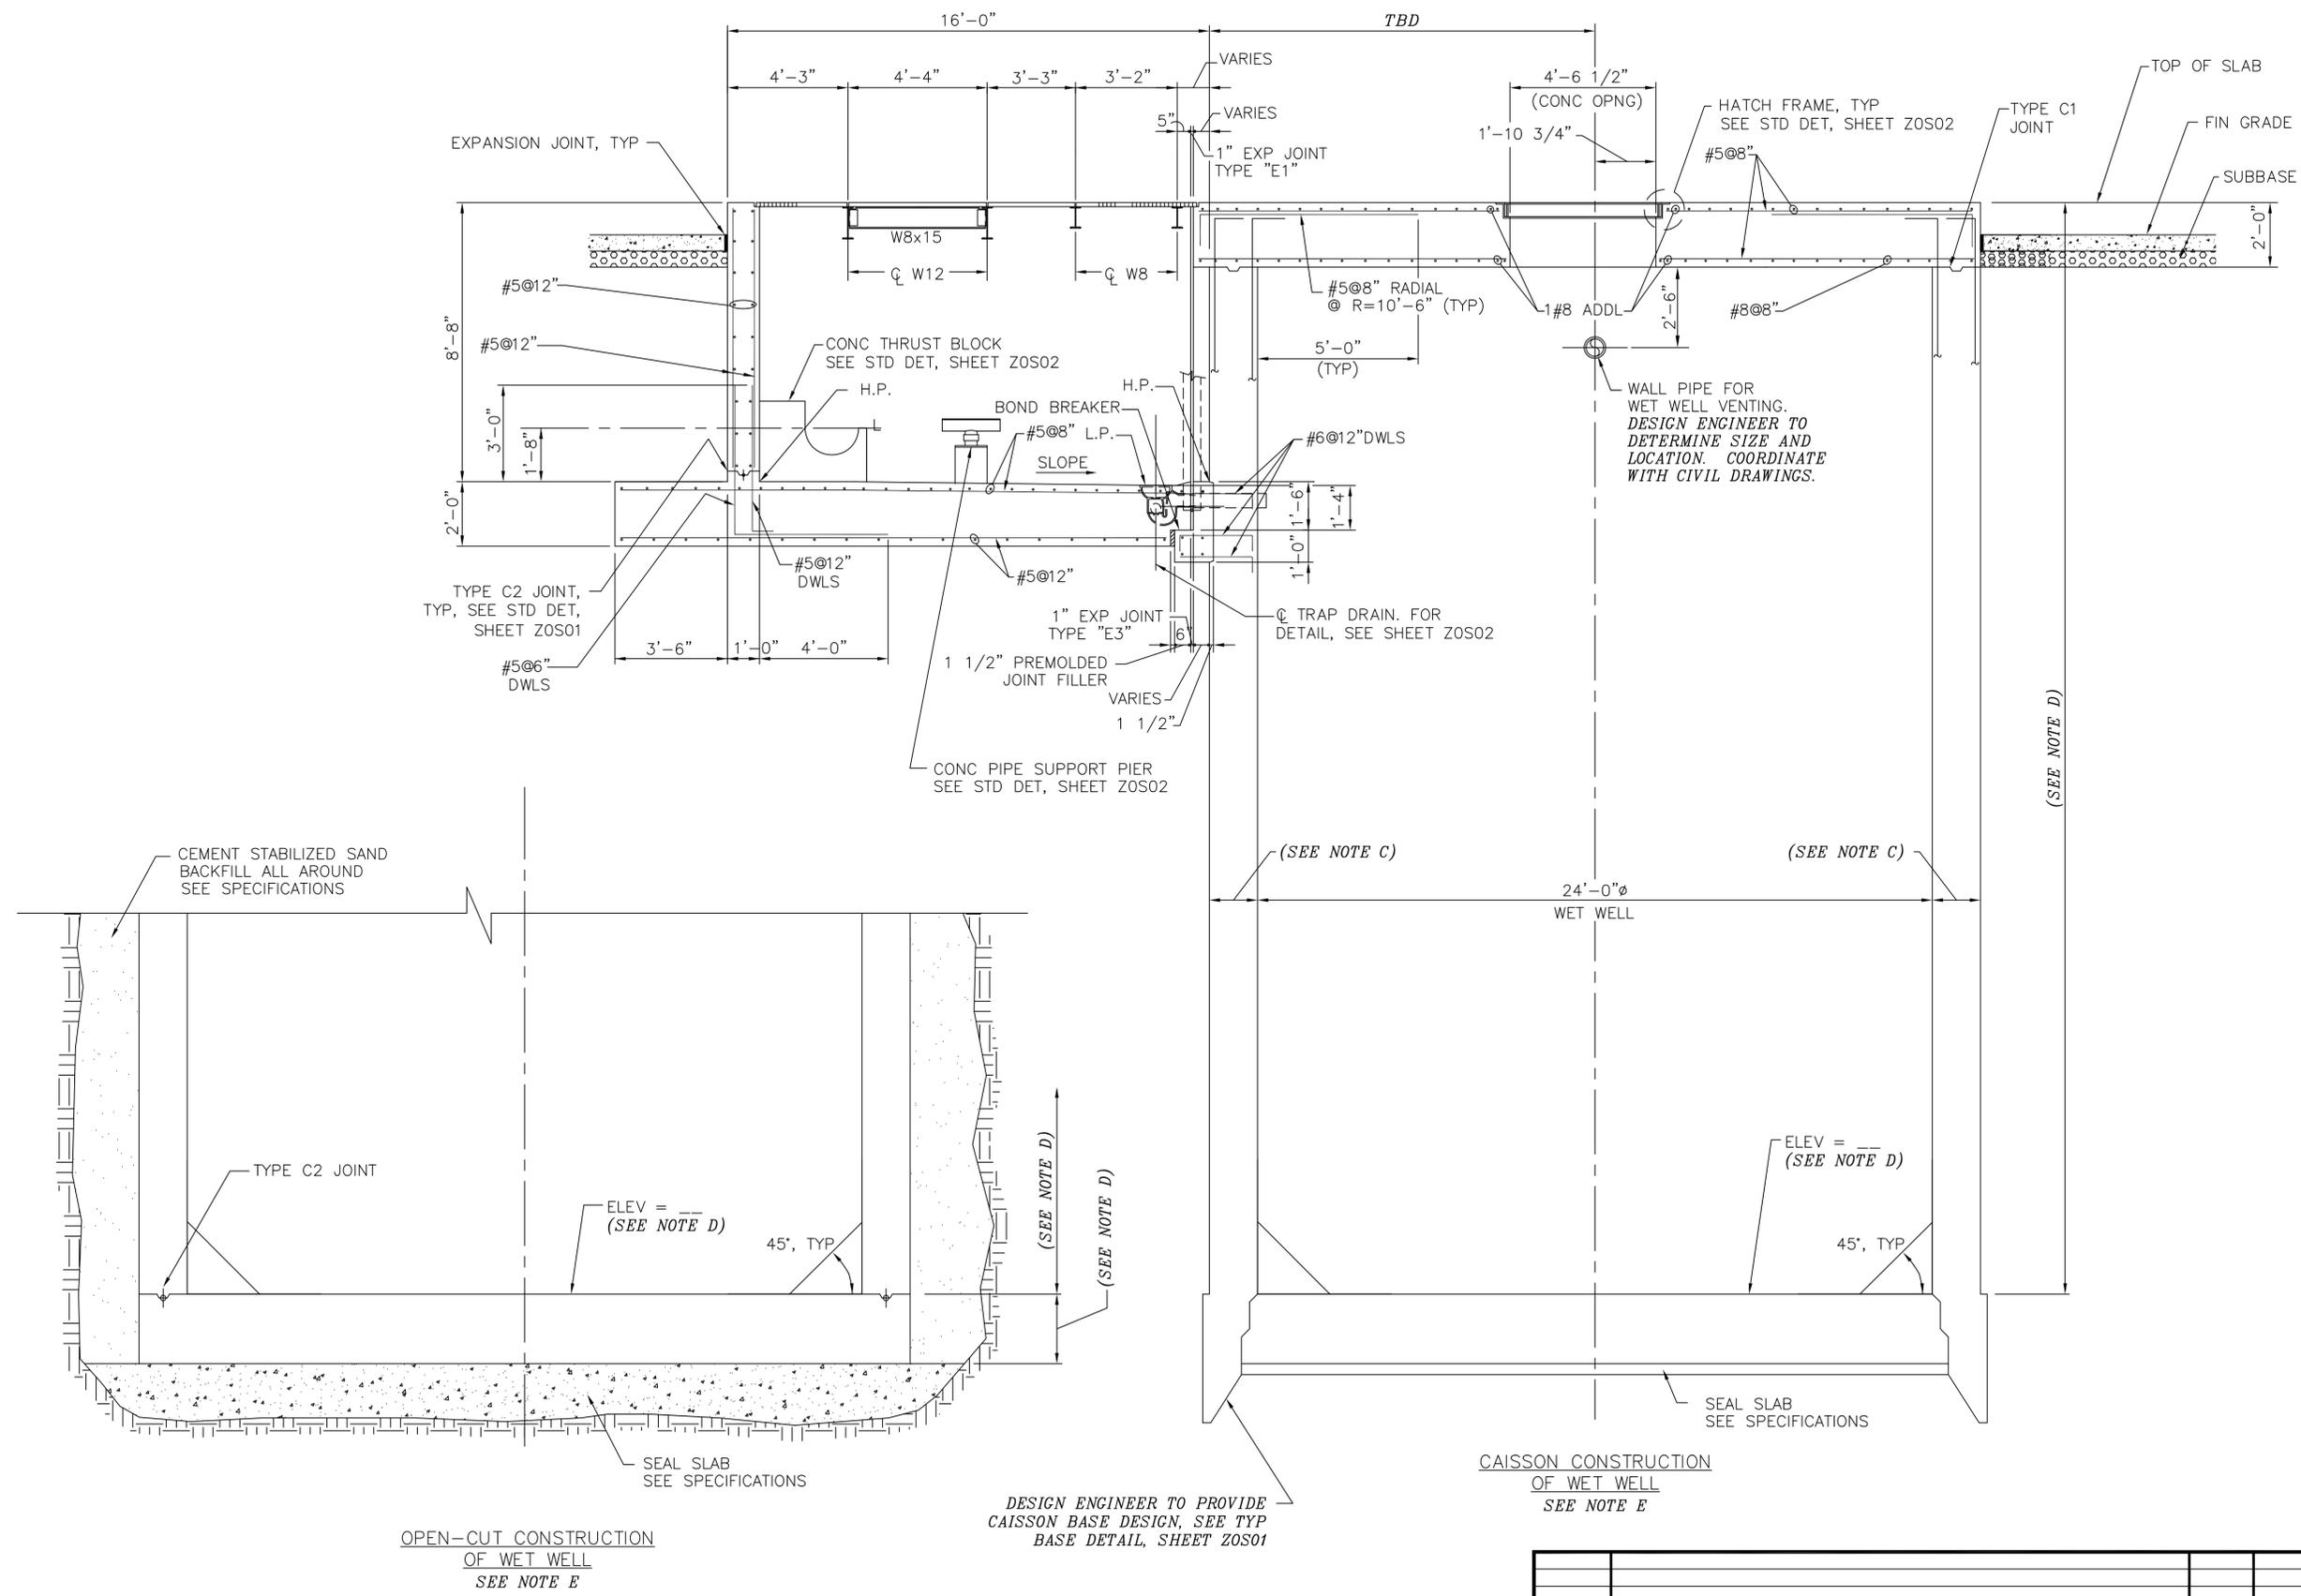

SECTION A
J2S01

| REV. NO. | DESCRIPTION | APP'D | DATE |
|----------|-------------|-------|------|
| | | | |
| | | | |
|----------------|-------------|----------------------|-------|
| SCALE: | XX" = 1'-0" | DESIGNED BY: | |
| SUBMITTED: | | DRAWN BY: | |
| DATE: | MARCH, 2013 | SHEET NO. OF SHEETS: | |
| SURVEY BY: | | DWG. NO. | J2S03 |
| FIELD BOOK NO. | | | |

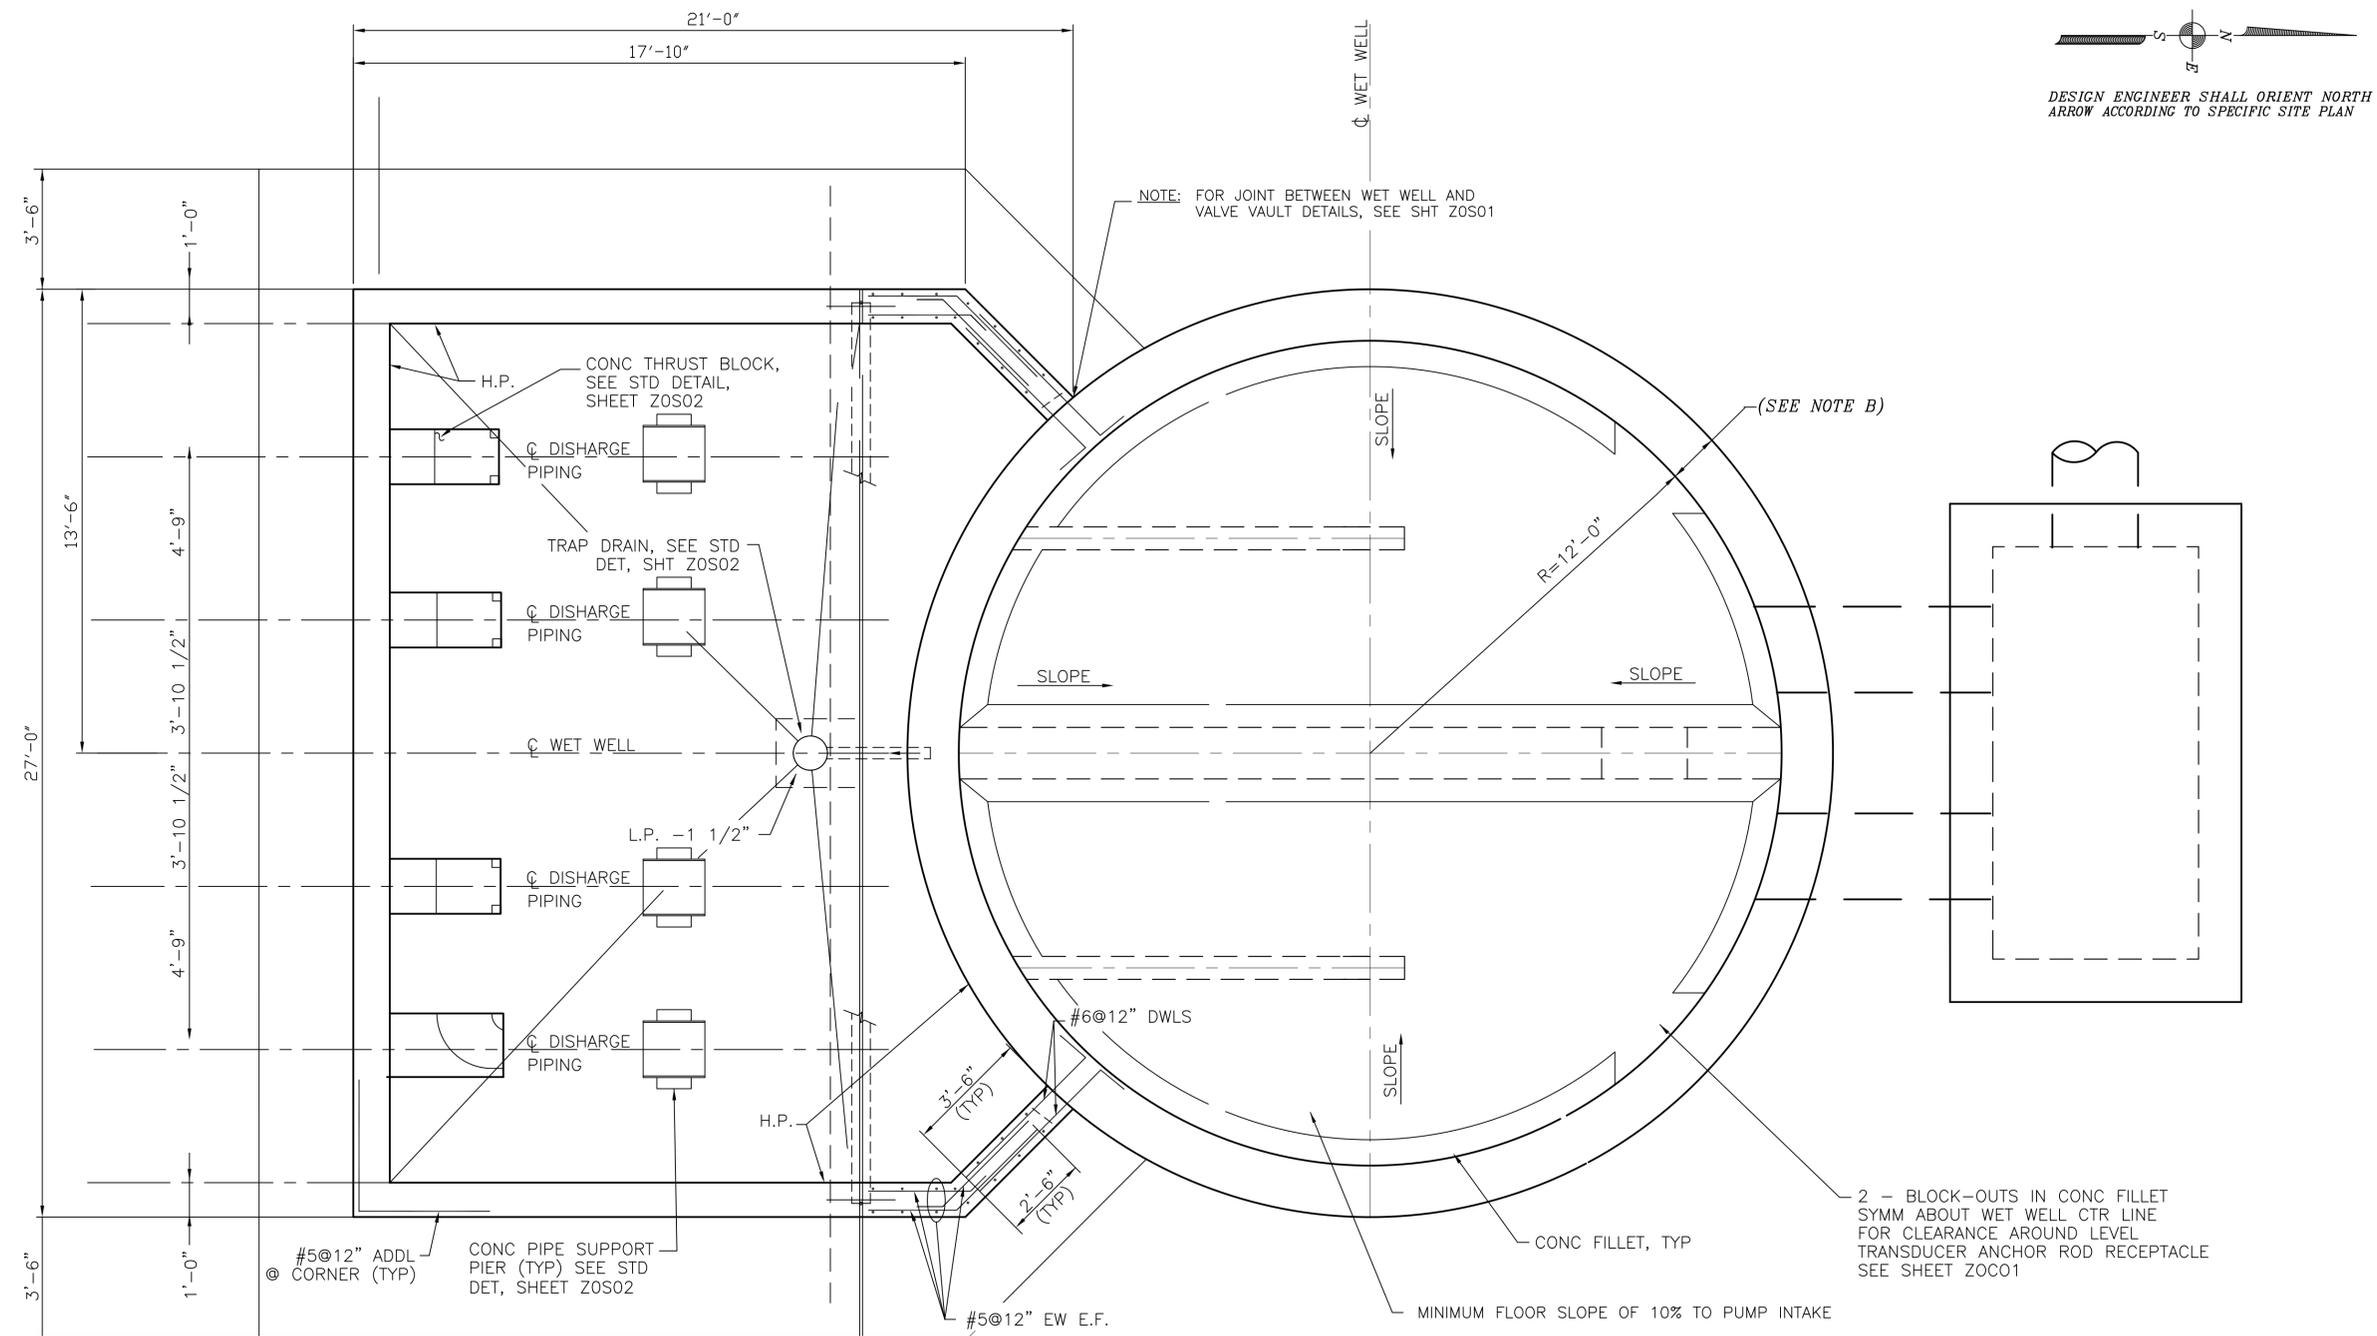

NOTES TO DESIGN ENGINEER:

- A. THESE LIFT STATION DRAWINGS ARE CONSIDERED TO BE DESIGN GUIDELINES FOR THE CONSTRUCTION OF CITY OF HOUSTON WASTEWATER SUBMERSIBLE LIFT STATIONS. THEIR INTENDED USE IS AS A FRAMEWORK FOR THE CONTRACTED DESIGN ENGINEER IN DEVELOPING SPECIFIC LIFT STATION DESIGNS. IT IS THE RESPONSIBILITY OF THE CONTRACTED DESIGN ENGINEER TO VERIFY THE COMPLETENESS AND ACCURACY OF THE INFORMATION HEREIN CONTAINED AND TO ADJUST ACCORDING TO PROJECT SPECIFIC REQUIREMENTS.
- B. DIMENSIONS AND REINFORCING NOT PROVIDED ARE TO BE DETERMINED BY THE DESIGN ENGINEER PER APPLICABLE PROJECT SPECIFIC REQUIREMENTS.
- C. SEE DETAIL AND CIVIL DRAWINGS FOR DIMENSIONS AND INFORMATION NOT SHOWN.
- D. THE DESIGN ENGINEER SHALL INCORPORATE ONLY THE NECESSARY STANDARD GUIDELINE DRAWINGS AND DETAILS INTO HIS PROJECT CONTRACT DOCUMENTATION PACKAGE, AND SHALL ADJUST PAGE NUMBERS AND CROSS REFERENCING ACCORDINGLY.
- E. THE DESIGN ENGINEER SHALL CONSULT THE CITY OF HOUSTON DESIGN GUIDELINES MANUAL, THE ENGINEERING DESIGN MANUAL, AND THE MASTER SPECIFICATIONS FOR FURTHER INSTRUCTIONS AND INFORMATION PERTINENT TO THESE STANDARD DESIGN GUIDELINE DRAWINGS.
- F. THE DESIGN ENGINEER SHALL REMOVE THESE NOTES, ALL REFERENCES TO THESE NOTES, AND ANY OTHER EXTRANEOUS INFORMATION FROM THE DESIGN GUIDELINE DRAWINGS. DESIGN ENGINEER SHALL PROVIDE ANY NOTES OR OTHER APPROPRIATE INFORMATION NECESSARY TO COMPLETE THE LIFT STATION DESIGN.

- NOTES:**
1. FOR ADDITIONAL REINFORCEMENT AT OPENINGS NOT SHOWN, SEE SHEET ZOS01.
 2. DIMENSIONS NOTED ARE RELATIVE TO THE PUMP SIZE AND MANUFACTURER SELECTED. CONTRACTOR SHALL CONFIRM.
 3. SEE DETAIL AND CIVIL DRAWINGS FOR DIMENSIONS AND INFORMATION NOT SHOWN.
 4. WET WELL TO BE LINED WITH CONCRETE PROTECTIVE LINER PER PROJECT SPECIFICATIONS, CONSULT WITH COH PROJECT MANAGER FOR APPROVED PRODUCTS. LINER SHALL COVER ALL CONCRETE SURFACES, AND SHALL EXTEND TO A MINIMUM OF 12" BELOW THE LOW WATER ELEVATION.

STRUCTURAL
4 PUMPS @ 800 - 3499 GPM PER PUMP
PREFERRED CONFIGURATION

PROJECT NO. R-000267-0XXX-X

TITLE CITY OF HOUSTON
DESIGN GUIDELINE DRAWINGS
FOR SUBMERSIBLE LIFT STATIONS

CITY OF HOUSTON
DEPARTMENT OF PUBLIC WORKS AND ENGINEERING
ENGINEERING AND CONSTRUCTION

DESIGN ENGINEER TO INCLUDE COH STANDARD TITLE BLOCK ON ALL DRAWINGS, SEE STANDARD TITLE BLOCK DETAIL ON SHEET ZOC0X

PLAN VIEW @ VAULT FLOOR

| REV. NO. | DESCRIPTION | APP'D | DATE |
|----------|-------------|-------|------|
| | | | |
| | | | |
| | |
|--------------------|---------------------|
| SCALE: XX" = 1'-0" | DESIGNED BY: |
| SUBMITTED: | DRAWN BY: |
| DATE: MARCH, 2013 | SHEET NO. OF SHEETS |
| SURVEY BY: | DWG. NO. J2S02 |
| FIELD BOOK NO. | |

CADD DWG. FILE NO. : J2S02.DWG

NOTES TO DESIGN ENGINEER:


- A. THESE LIFT STATION DRAWINGS ARE CONSIDERED TO BE DESIGN GUIDELINES FOR THE CONSTRUCTION OF CITY OF HOUSTON WASTEWATER SUBMERSIBLE LIFT STATIONS. THEIR INTENDED USE IS AS A FRAMEWORK FOR THE CONTRACTED DESIGN ENGINEER IN DEVELOPING SPECIFIC LIFT STATION DESIGNS. IT IS THE RESPONSIBILITY OF THE CONTRACTED DESIGN ENGINEER TO VERIFY THE COMPLETENESS AND ACCURACY OF THE INFORMATION HEREIN CONTAINED AND TO ADJUST ACCORDING TO PROJECT SPECIFIC REQUIREMENTS.
- B. DESIGN ENGINEER TO VERIFY SIZE AND LOCATION OF THE ACCESS HATCH OPENINGS PER SELECTED HATCH AND PUMP MANUFACTURERS' REQUIREMENTS.
- C. DIMENSIONS NOTED ARE RELATIVE TO THE PUMP SIZE AND MANUFACTURER SELECTED. DESIGN ENGINEER SHALL VERIFY.
- D. DIMENSIONS AND REINFORCING NOT PROVIDED ARE TO BE DETERMINED BY THE DESIGN ENGINEER PER APPLICABLE SITE REQUIREMENTS.
- E. SEE DETAIL AND CIVIL DRAWINGS FOR DIMENSIONS AND INFORMATION NOT SHOWN.
- F. THE DESIGN ENGINEER SHALL INCORPORATE ONLY THE NECESSARY STANDARD GUIDELINE DRAWINGS AND DETAILS INTO HIS PROJECT CONTRACT DOCUMENTATION PACKAGE, AND SHALL ADJUST PACE NUMBERS AND CROSS REFERENCING ACCORDINGLY.
- G. THE DESIGN ENGINEER SHALL CONSULT THE CITY OF HOUSTON DESIGN GUIDELINES MANUAL, THE ENGINEERING DESIGN MANUAL, AND THE MASTER SPECIFICATIONS FOR FURTHER INSTRUCTIONS AND INFORMATION PERTINENT TO THESE STANDARD DESIGN GUIDELINE DRAWINGS.
- H. THE DESIGN ENGINEER SHALL REMOVE THESE NOTES, ALL REFERENCES TO THESE NOTES, AND ANY OTHER EXTRANEOUS INFORMATION FROM THE DESIGN GUIDELINE DRAWINGS. DESIGN ENGINEER SHALL PROVIDE ANY NOTES OR OTHER APPROPRIATE INFORMATION NECESSARY TO COMPLETE THE LIFT STATION DESIGN.
- I. THE DESIGN ENGINEER SHALL ENSURE GUARDRAIL AND CATWALK MEET THE REQUIREMENTS FOR "AREAS NOT OPEN TO PUBLIC" AS PROVIDED BY THE U.S. OCCUPATIONAL SAFETY & HEALTH ADMINISTRATION (OSHA) AND LATEST COH CODE ENFORCEMENT APPROVED VERSION OF THE INTERNATIONAL BUILDING CODE (IBC).
- J. THE DESIGN ENGINEER SHALL PROVIDE GUARDRAILS FOR ANY WALKING SURFACES WITH A POTENTIAL FALL DISTANCE EQUAL TO OR GREATER THAN 30 INCHES.

NOTES:

1. FOR ADDITIONAL REINFORCEMENT AT OPENINGS NOT SHOWN, SEE SHEET Z0S01.
2. CONTRACTOR TO CONFIRM SIZE AND LOCATION OF THE ACCESS HATCH OPENINGS PER SELECTED HATCH AND PUMP MANUFACTURERS' REQUIREMENTS.
3. DIMENSIONS NOTED ARE RELATIVE TO THE PUMP SIZE AND MANUFACTURER SELECTED. CONTRACTOR SHALL CONFIRM.
4. SEE DETAIL AND CIVIL DRAWINGS FOR DIMENSIONS AND INFORMATION NOT SHOWN.
5. WET WELL TO BE LINED WITH CONCRETE PROTECTIVE LINER PER PROJECT SPECIFICATIONS, CONSULT WITH COH PROJECT MANAGER FOR APPROVED PRODUCTS. LINER SHALL COVER ALL CONCRETE SURFACES, AND SHALL EXTEND TO A MINIMUM OF 12" BELOW THE LOW WATER ELEVATION.

| | |
|--|---|
| STRUCTURAL | |
| 4 PUMPS @ 800 - 3499 GPM PER PUMP PREFERRED CONFIGURATION | |
| PROJECT NO. | R-000267-0XXX-X |
| TITLE | CITY OF HOUSTON DESIGN GUIDELINE DRAWINGS FOR SUBMERSIBLE LIFT STATIONS |
| CITY OF HOUSTON | |
| DEPARTMENT OF PUBLIC WORKS AND ENGINEERING ENGINEERING AND CONSTRUCTION | |

DESIGN ENGINEER TO INCLUDE COH STANDARD TITLE BLOCK ON ALL DRAWINGS, SEE STANDARD TITLE BLOCK DETAIL ON SHEET ZOCOX

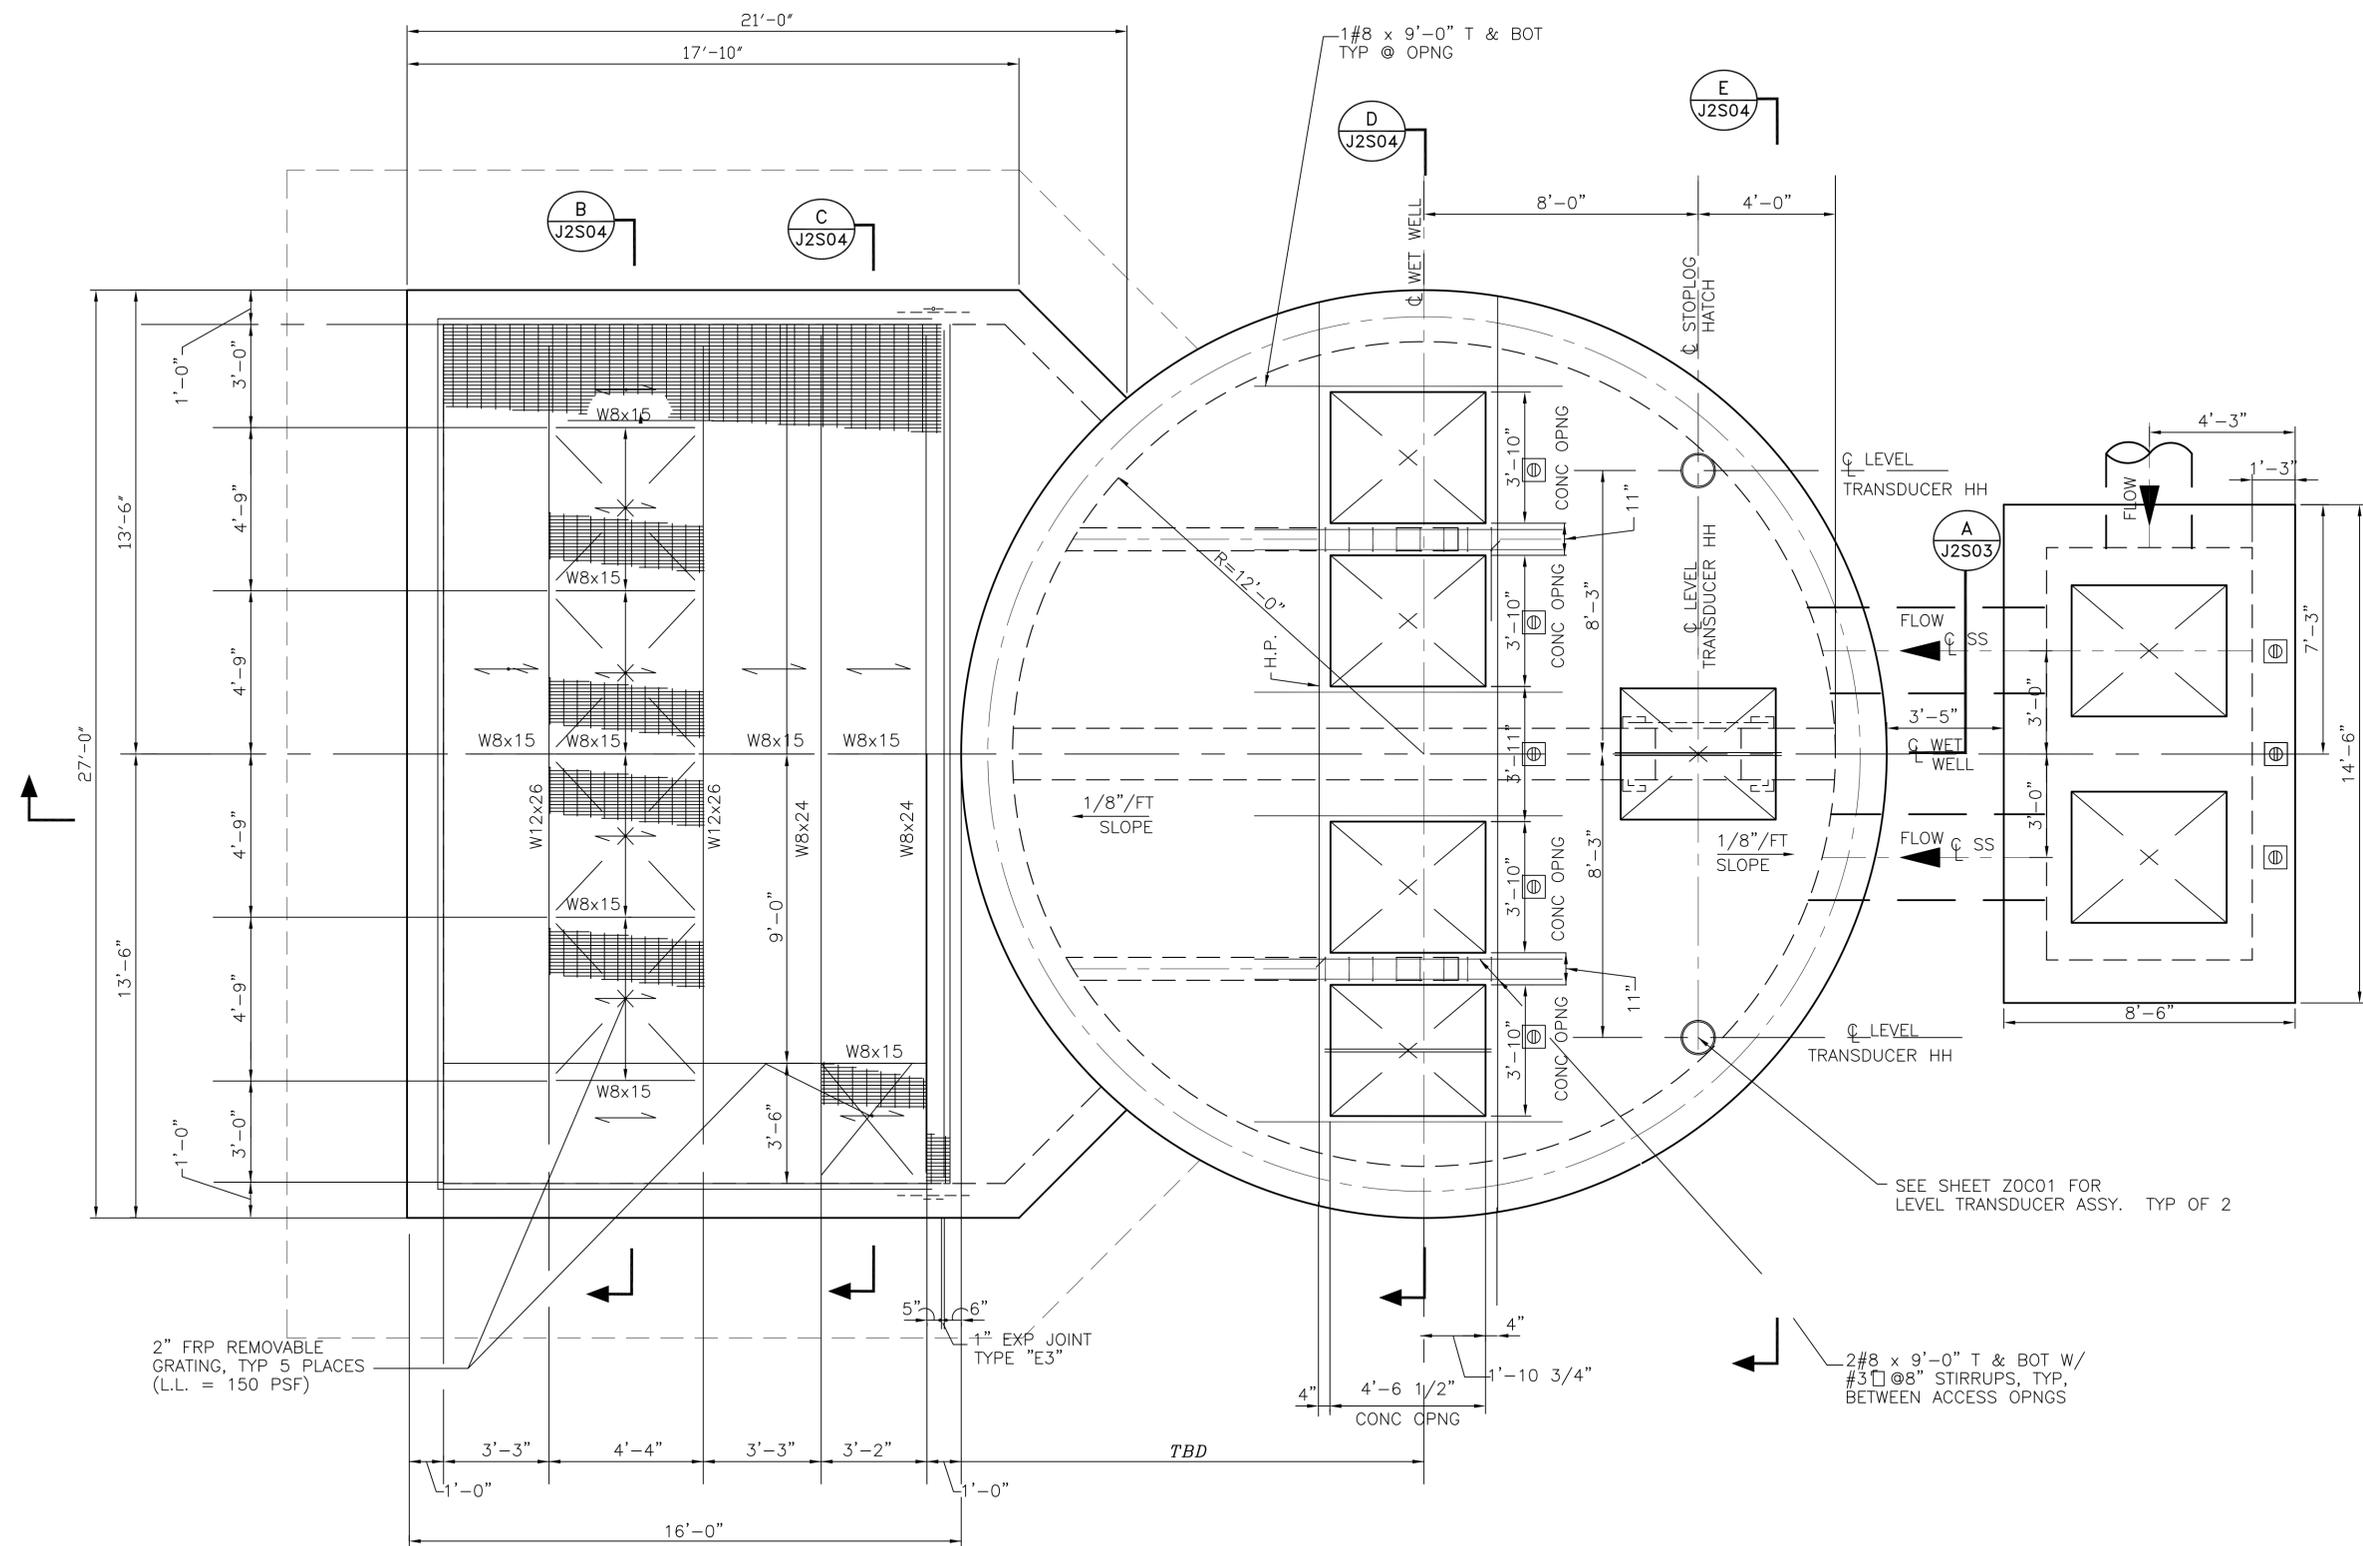

PLAN VIEW @ GRADE

| REV. NO. | DESCRIPTION | APP'D | DATE |
|----------|-------------|-------|------|
| | | | |
| | | | |
| | | | |
| | | | |

| | | | |
|-----------------|-------------|----------------------|-------|
| SCALE: | XX" = 1'-0" | DESIGNED BY: | |
| SUBMITTED: | | DRAWN BY: | |
| DATE: | MARCH, 2013 | SHEET NO. OF SHEETS: | |
| SURVEY BY: | | DWG. NO.: | J2S01 |
| FIELD BOOK NO.: | | | |

CADD DWG. FILE NO. : J2S01.DWG

RESTRAINED FLANGED
COUPLING ADAPTOR (TYP)
SEE DETAIL

AIR & VACUUM VALVE & PIPING @
SEE DETAIL
NOTE:
DESIGN ENGINEER TO DETERMINE NECESSITY
OF A&VV PER DESIGN GUIDELINES MANUAL

CLAMP AIR RELEASE VALVE
DISCHARGE PIPING TO VALVE VAULT
WALL USING 316 SS CLIP TYPE
HANGER & TYPE 316 SS CONC
ANCHOR BOLTS

DISCHARGE PIPING SUPPORT
SEE SHEET ZOC04

DESIGN ENGINEER SHALL ORIENT NORTH
ARROW ACCORDING TO SPECIFIC SITE PLAN

INSTALL PRESSURE GAUGE SUITABLE
FOR WASTEWATER APPLICATION

LEVEL TRANSDUCER
SUPPORT/ GUIDE
ASSY, TYP SEE SHT ZOC01

WALLPIPE WITH
WATER STOP COLLAR

AIR RELEASE
VALVE & PIPING
SEE DETAIL

PLUG VALVE, TYP

CHECK VALVE, TYP

TRAP DRAIN, SEE
DETAIL SHEET ZOC02

SPOOL, TYP

WALL PIPE WITH
WATER STOP COLLAR
(TYP)

ENTRY ACCESS LADDER,
SEE SHEET ZOC05

SAN. SEWER
INFLUENT

CONC. SPLITTER BOX

STOP LOG
GUIDES (TYP)

FLOW

FLOW

INFLUENT
SEWER (TYP X 2)

STOP LOG
STORAGE


STOP LOG
GUIDES (TYP)

STOP LOG
STORAGE

CONC FILLET,
TYP.

8" THICK BAFFLE WALL., TYP.

8'-0"
INNER WET WELL WALL AT CL
TO END OF BAFFLE WALLS

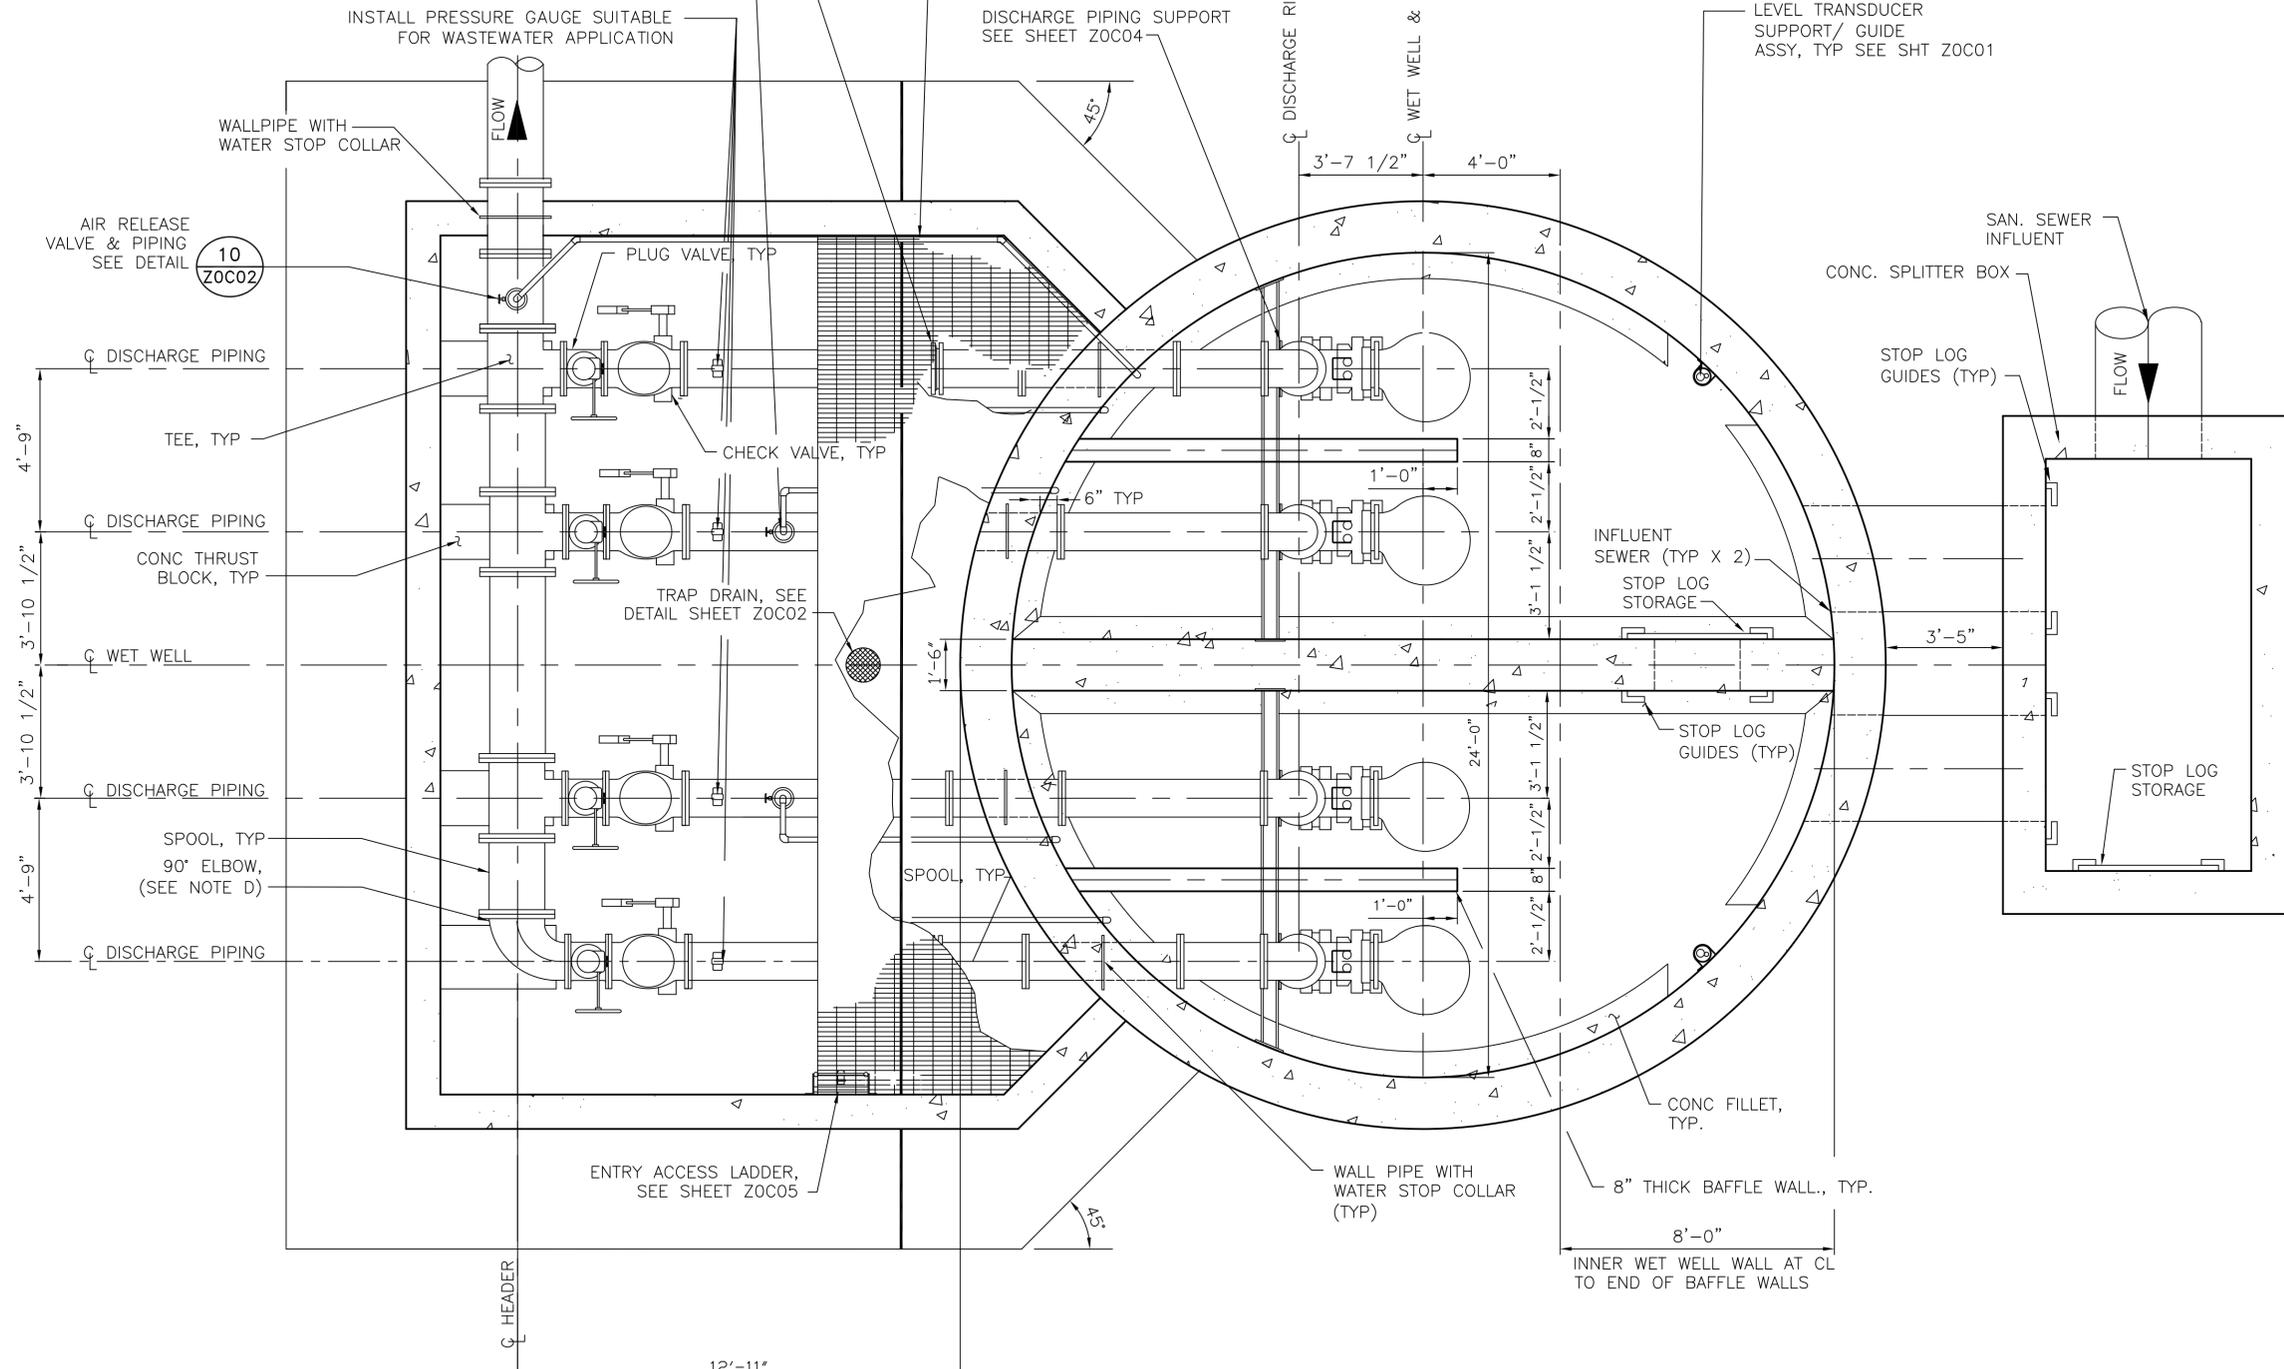

NOTES TO DESIGN ENGINEER:

A. THESE LIFT STATION DRAWINGS ARE CONSIDERED TO BE DESIGN GUIDELINES FOR THE CONSTRUCTION OF CITY OF HOUSTON WASTEWATER SUBMERSIBLE LIFT STATIONS. THEIR INTENDED USE IS AS A FRAMEWORK FOR THE CONTRACTED DESIGN ENGINEER IN DEVELOPING SPECIFIC LIFT STATION DESIGNS. IT IS THE RESPONSIBILITY OF THE CONTRACTED DESIGN ENGINEER TO VERIFY THE COMPLETENESS AND ACCURACY OF THE INFORMATION HEREIN CONTAINED AND TO ADJUST ACCORDING TO PROJECT SPECIFIC REQUIREMENTS.

B. THIS DESIGN IS BASED UPON THE LARGEST CAPACITY PUMP FOR THIS STANDARD (RANGE: 800 - 3499)

C. LIFT STATION DESIGN IS BASED UPON 10"-20" NOMINAL PUMP, VALVES AND PIPING AS THE SIZES RECOMMENDED FOR THIS STANDARD STATION. THE DESIGN WILL ACCOMMODATE VALVES AND PIPING IF PROJECT SPECIFIC CONDITIONS REQUIRE.

D. REPLACE THE 90° ELBOW WITH A FLANGED TEE FOR CONNECTION TO SURGE RELIEF VALVE, IF REQUIRED. SEE DETAILS, SHEET ZOC06.

E. DIMENSIONS NOTED ARE RELATIVE TO THE PUMP SIZE AND MANUFACTURER SELECTED. DESIGN ENGINEER SHALL VERIFY.

F. SEE DETAIL AND STRUCTURAL DRAWINGS FOR DIMENSIONS AND INFORMATION NOT SHOWN.

G. THE DESIGN ENGINEER SHALL INCORPORATE ONLY THE NECESSARY STANDARD GUIDELINE DRAWINGS AND DETAILS INTO HIS PROJECT CONTRACT DOCUMENTATION PACKAGE, AND SHALL ADJUST PAGE NUMBERS AND CROSS REFERENCING ACCORDINGLY.

H. THE DESIGN ENGINEER SHALL CONSULT THE CITY OF HOUSTON DESIGN GUIDELINES MANUAL, THE ENGINEERING DESIGN MANUAL, AND THE MASTER SPECIFICATIONS FOR FURTHER INSTRUCTIONS AND INFORMATION PERTINENT TO THESE STANDARD DESIGN GUIDELINE DRAWINGS.

I. THE DESIGN ENGINEER SHALL REMOVE THESE NOTES, ALL REFERENCES TO THESE NOTES, AND ANY OTHER EXTRANEOUS INFORMATION FROM THE DESIGN GUIDELINE DRAWINGS. DESIGN ENGINEER SHALL PROVIDE ANY NOTES OR OTHER APPROPRIATE INFORMATION NECESSARY TO COMPLETE THE LIFT STATION DESIGN.

- NOTES:**
- SEE DETAIL AND STRUCTURAL DRAWINGS FOR DIMENSIONS AND INFORMATION NOT SHOWN.
 - DIMENSIONS NOTED ARE RELATIVE TO THE PUMP SIZE AND MANUFACTURER SELECTED. CONTRACTOR SHALL CONFIRM.
 - INSTALL PLUG VALVES TO OPEN UPWARD AND TO CLOSE TO A SEATING POSITION.
 - INSTALL CHECK VALVES SO THAT THE WEIGHT LEVER POSITION IS APPROXIMATELY 45° BELOW THE VALVE HORIZONTAL CENTER LINE IN THE CLOSED POSITION; AND APPROXIMATELY 45° ABOVE THE VALVE HORIZONTAL CENTER LINE IN THE FULL OPEN POSITION.
 - SLEEVED OR CORED DISCHARGE PIPE OPENINGS SEALED WITH LINK-SEAL (OR APPROVED EQUAL) MAY BE SUBSTITUTED FOR POURED IN PLACE WALL PIPES TO ACCOMMODATE CONSTRUCTION METHOD.

BASE SECTION
4 PUMPS @ 800 - 3499 GPM PER PUMP
PREFERRED CONFIGURATION

PROJECT NO. R-000267-0XXX-X

TITLE CITY OF HOUSTON
DESIGN GUIDELINE DRAWINGS
FOR SUBMERSIBLE LIFT STATIONS

CITY OF HOUSTON
DEPARTMENT OF PUBLIC WORKS AND ENGINEERING
ENGINEERING AND CONSTRUCTION

DESIGN ENGINEER TO INCLUDE COH
STANDARD TITLE BLOCK ON ALL
DRAWINGS, SEE STANDARD TITLE
BLOCK DETAIL ON SHEET ZOC0X



SECTION **B**
J2C02

| | | | |
|------------|-------------|---------------------|-------|
| SCALE: | XX" = 1'-0" | DESIGNED BY: | |
| SUBMITTED: | | DRAWN BY: | |
| DATE: | MARCH, 2013 | SHEET NO. OF SHEETS | |
| SURVEY BY: | | DWG. NO. | J2C03 |
| REV. NO. | | FIELD BOOK NO. | |
| | DESCRIPTION | APP'D | DATE |

CADD DWG. FILE NO. : J2C03.DWG

COHSTD.BDR 0 1 2 3

ORIGINAL SCALE IN INCHES FOR REDUCED PLANS DESIGN ENGINEER TO UPDATE BAR SCALE TO REFLECT ACTUAL SCALE ON THE DRAWING.

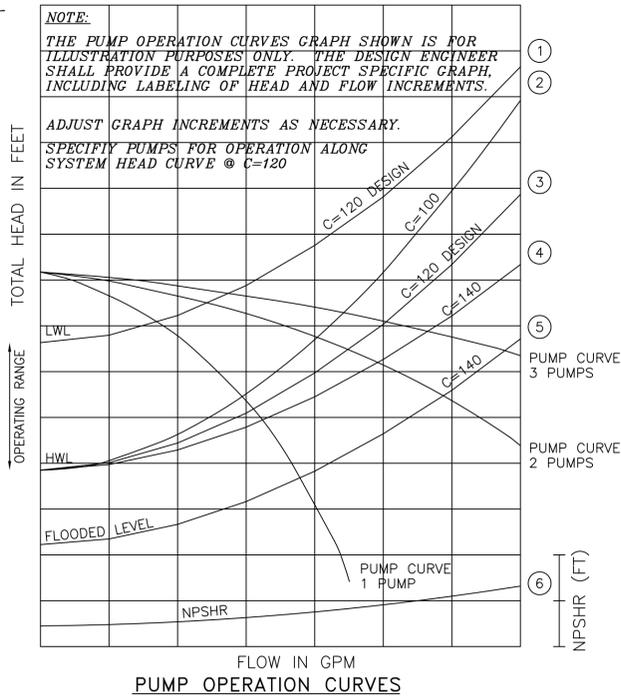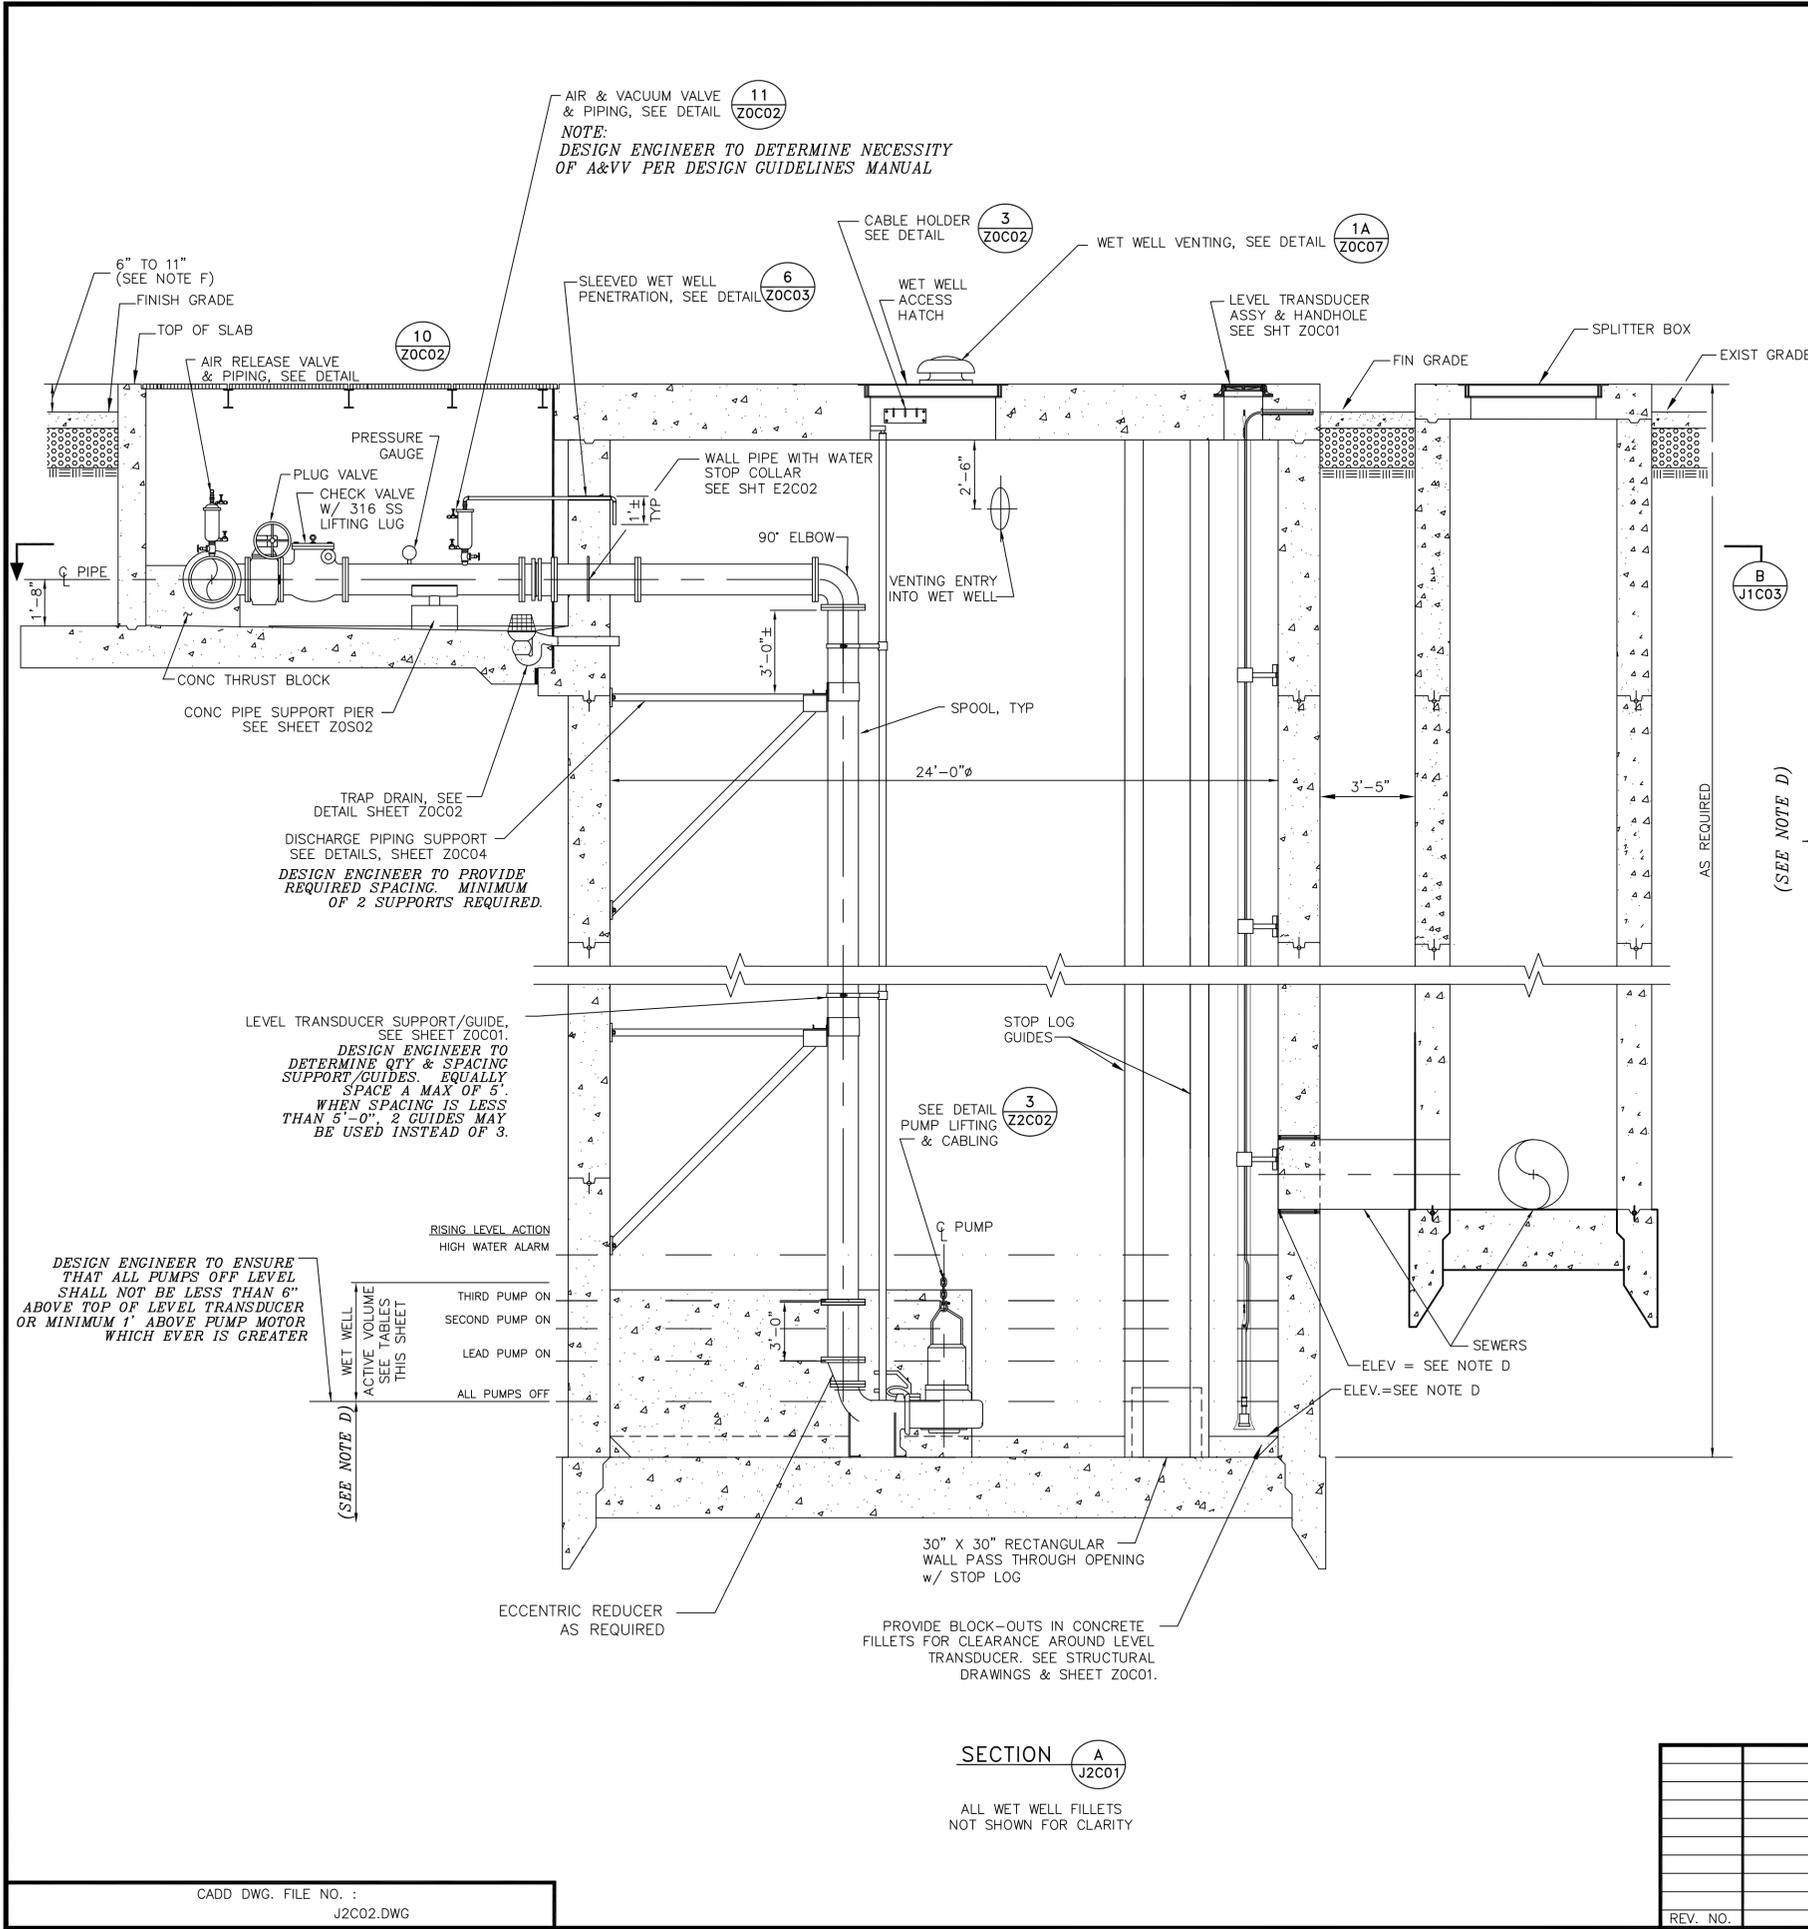

- PUMP CURVE NOTES:**
1. LOW NORMAL OPERATING LEVEL C=120 - DESIGN.
 2. HIGH NORMAL OPERATING LEVEL C=100 - INFORMATION ONLY (TCEQ)
 3. HIGH NORMAL OPERATING LEVEL C=120 - DESIGN
 4. HIGH NORMAL OPERATING LEVEL C=140 - INFORMATION ONLY
 5. EMERGENCY FLOODED OPERATING LEVEL C=140 - MAXIMUM DISCHARGE
 6. NET POSITIVE SUCTION HEAD REQUIRED (NPSHR) BASED ON NORMAL OPERATING WATER LEVELS
 7. PUMP CURVES ARE MODIFIED FOR STATION LOSSES.

PUMP DATA TABLE

| PUMP CHARACTERISTICS | PUMP NO. 1 | PUMP NO. 2 | PUMP NO. 3 | PUMP NO. 4 |
|---|------------|------------|------------|------------|
| MOTOR DATA NOMINAL SIZE (HP) MAX SPEED (RPM) | | | | |
| SOLIDS PASSAGE MIN SPHERE (IN) | | | | |
| CAPACITY (GPM) DESIGN RUNOUT | | | | |
| DISCHARGE HEAD (FT) DESIGN RUNOUT SHUT OFF | | | | |
| EFFICIENCY (%) DESIGN | | | | |
| NPSHR (FT) DESIGN RUNOUT | | | | |
| PUMP CYCLE TIME | | | | |

STATION OPERATION TABLES

| RISING LEVEL CYCLE | | |
|-----------------------|-----------------------------|---|
| WATER LEVEL ELEVATION | ACTION | PUMP(S) IN OPERATION |
| | PUMPS OFF LEVEL - NO ACTION | ALL PUMPS ARE OFF |
| | LEAD PUMP TURNS ON | LEAD PUMP ON |
| | SECOND PUMP TURNS ON | LEAD & SECOND PUMPS ON |
| | THIRD PUMP TURNS ON | LEAD, SECOND & THIRD PUMPS ON |
| | HIGH WATER ALARM ON | HIGH WATER ALARM SOUND |
| FALLING LEVEL CYCLE | | |
| WATER LEVEL ELEVATION | ACTION | PUMP(S) IN OPERATION |
| | HIGH WATER LEVEL ALARM OFF | LEAD, SECOND & THIRD PUMPS ON |
| | LEAD PUMP TURNS OFF | SECOND & THIRD PUMPS ON |
| | SECOND PUMP TURNS OFF | THIRD PUMP ON |
| | THIRD PUMP TURNS OFF | ALL PUMPS STOPPED - STANDBY PUMP SWITCHES TO LEAD PUMP |

NOTES TO DESIGN ENGINEER:

- THESE LIFT STATION DRAWINGS ARE CONSIDERED TO BE DESIGN GUIDELINES FOR THE CONSTRUCTION OF CITY OF HOUSTON WASTEWATER SUBMERSIBLE LIFT STATIONS. THEIR INTENDED USE IS AS A FRAMEWORK FOR THE CONTRACTED DESIGN ENGINEER IN DEVELOPING SPECIFIC LIFT STATION DESIGNS.
- IT IS THE RESPONSIBILITY OF THE CONTRACTED DESIGN ENGINEER TO VERIFY THE COMPLETENESS AND ACCURACY OF THE INFORMATION HEREIN CONTAINED AND TO ADJUST ACCORDING TO PROJECT SPECIFIC REQUIREMENTS.
- THIS DESIGN IS BASED UPON THE LARGEST CAPACITY PUMP FOR THIS STANDARD (RANGE: 800 - 3499 GPM PER PUMP).
- LIFT STATION DESIGN IS BASED UPON 10"-20" NOMINAL PUMP VALVES AND PIPING AS THE SIZES RECOMMENDED FOR THIS STANDARD STATION. THE DESIGN WILL ACCOMMODATE VALVES AND PIPING IF PROJECT SPECIFIC CONDITIONS REQUIRE.
- ELEVATIONS AND INFORMATION OMITTED ARE DETERMINED BY DESIGN ENGINEER FOR PROJECT SPECIFIC REQUIREMENTS.
- DIMENSIONS NOTED ARE RELATIVE TO THE PUMP SIZE AND MANUFACTURER SELECTED. DESIGN ENGINEER SHALL VERIFY DESIGN ENGINEER SHALL PROVIDE RAISED PUMP BASE IF REQUIRED.
- WHERE FLOOD PLAIN CONDITIONS REQUIRE THE TOP SLAB TO BE GREATER THAN 0" ABOVE FINISHED GRADE, DESIGN ENGINEER SHALL PROVIDE CONCRETE STAIRS.
- SEE DETAIL AND STRUCTURAL DRAWINGS FOR DIMENSIONS AND INFORMATION NOT SHOWN.
- THE DESIGN ENGINEER SHALL INCORPORATE ONLY THE NECESSARY STANDARD GUIDELINE DRAWINGS AND DETAILS INTO HIS PROJECT CONTRACT DOCUMENTATION PACKAGE, AND SHALL ADJUST PAGE NUMBERS AND CROSS REFERENCING ACCORDINGLY.
- THE DESIGN ENGINEER SHALL CONSULT THE CITY OF HOUSTON DESIGN GUIDELINES MANUAL, THE ENGINEERING DESIGN MANUAL, AND THE MASTER SPECIFICATIONS FOR FURTHER INSTRUCTIONS AND INFORMATION PERTINENT TO THESE STANDARD DESIGN GUIDELINE DRAWINGS.
- THE DESIGN ENGINEER SHALL REMOVE THESE NOTES, ALL REFERENCES TO THESE NOTES, AND ANY OTHER EXTRANEOUS INFORMATION FROM THE DESIGN GUIDELINE DRAWINGS. DESIGN ENGINEER SHALL PROVIDE ANY NOTES OR OTHER APPROPRIATE INFORMATION NECESSARY TO COMPLETE THE LIFT STATION DESIGN.

NOTES:

- DIMENSIONS NOTED ARE RELATIVE TO THE PUMP SIZE AND MANUFACTURER SELECTED. CONTRACTOR SHALL CONFIRM.
- SEE DETAIL AND STRUCTURAL DRAWINGS FOR DIMENSIONS AND INFORMATION NOT SHOWN.
- PUMP ANCHOR BOLTS ARE TO BE ADHESIVE TYPE, AND EMBEDDED IN CONCRETE SLAB. CONTRACTOR TO SUBMIT DESIGN OF PUMP ANCHOR BOLTS AND PATTERN, INCLUDING CALCULATIONS, DURING SHOP DRAWING SUBMISSION.
- CONTRACTOR TO PROVIDE ADHESIVE ANCHORS IN LIEU OF WEDGE ANCHORS FOR ALL SUBMERGED CONDITIONS. AND SUBMIT DESIGN OF ANCHOR BOLTS DURING SHOP DRAWING SUBMISSION.
- ALL PIPING IN THE WET WELL SHALL BE FLANGED. NO FLANGED COUPLING ADAPTORS, OR VICTAULIC STYLE COUPLINGS SHALL BE PERMITTED INSIDE THE WET WELL.

ELEVATION SECTION
4 PUMPS @800 - 3499 GPM PER PUMP
PREFERRED CONFIGURATION



PROJECT NO. R-000267-0XXX-X

TITLE CITY OF HOUSTON
DESIGN GUIDELINE DRAWINGS
FOR SUBMERSIBLE LIFT STATIONS

CITY OF HOUSTON
DEPARTMENT OF PUBLIC WORKS AND ENGINEERING
ENGINEERING AND CONSTRUCTION

DESIGN ENGINEER TO INCLUDE COH STANDARD TITLE BLOCK ON ALL DRAWINGS, SEE STANDARD TITLE BLOCK DETAIL ON SHEET ZOC0X

SCALE: XX" = 1'-0" DESIGNED BY:
SUBMITTED: DRAWN BY:
DATE: MARCH, 2013 SHEET NO. OF SHEETS
SURVEY BY: DWG. NO. J2C02
FIELD BOOK NO.

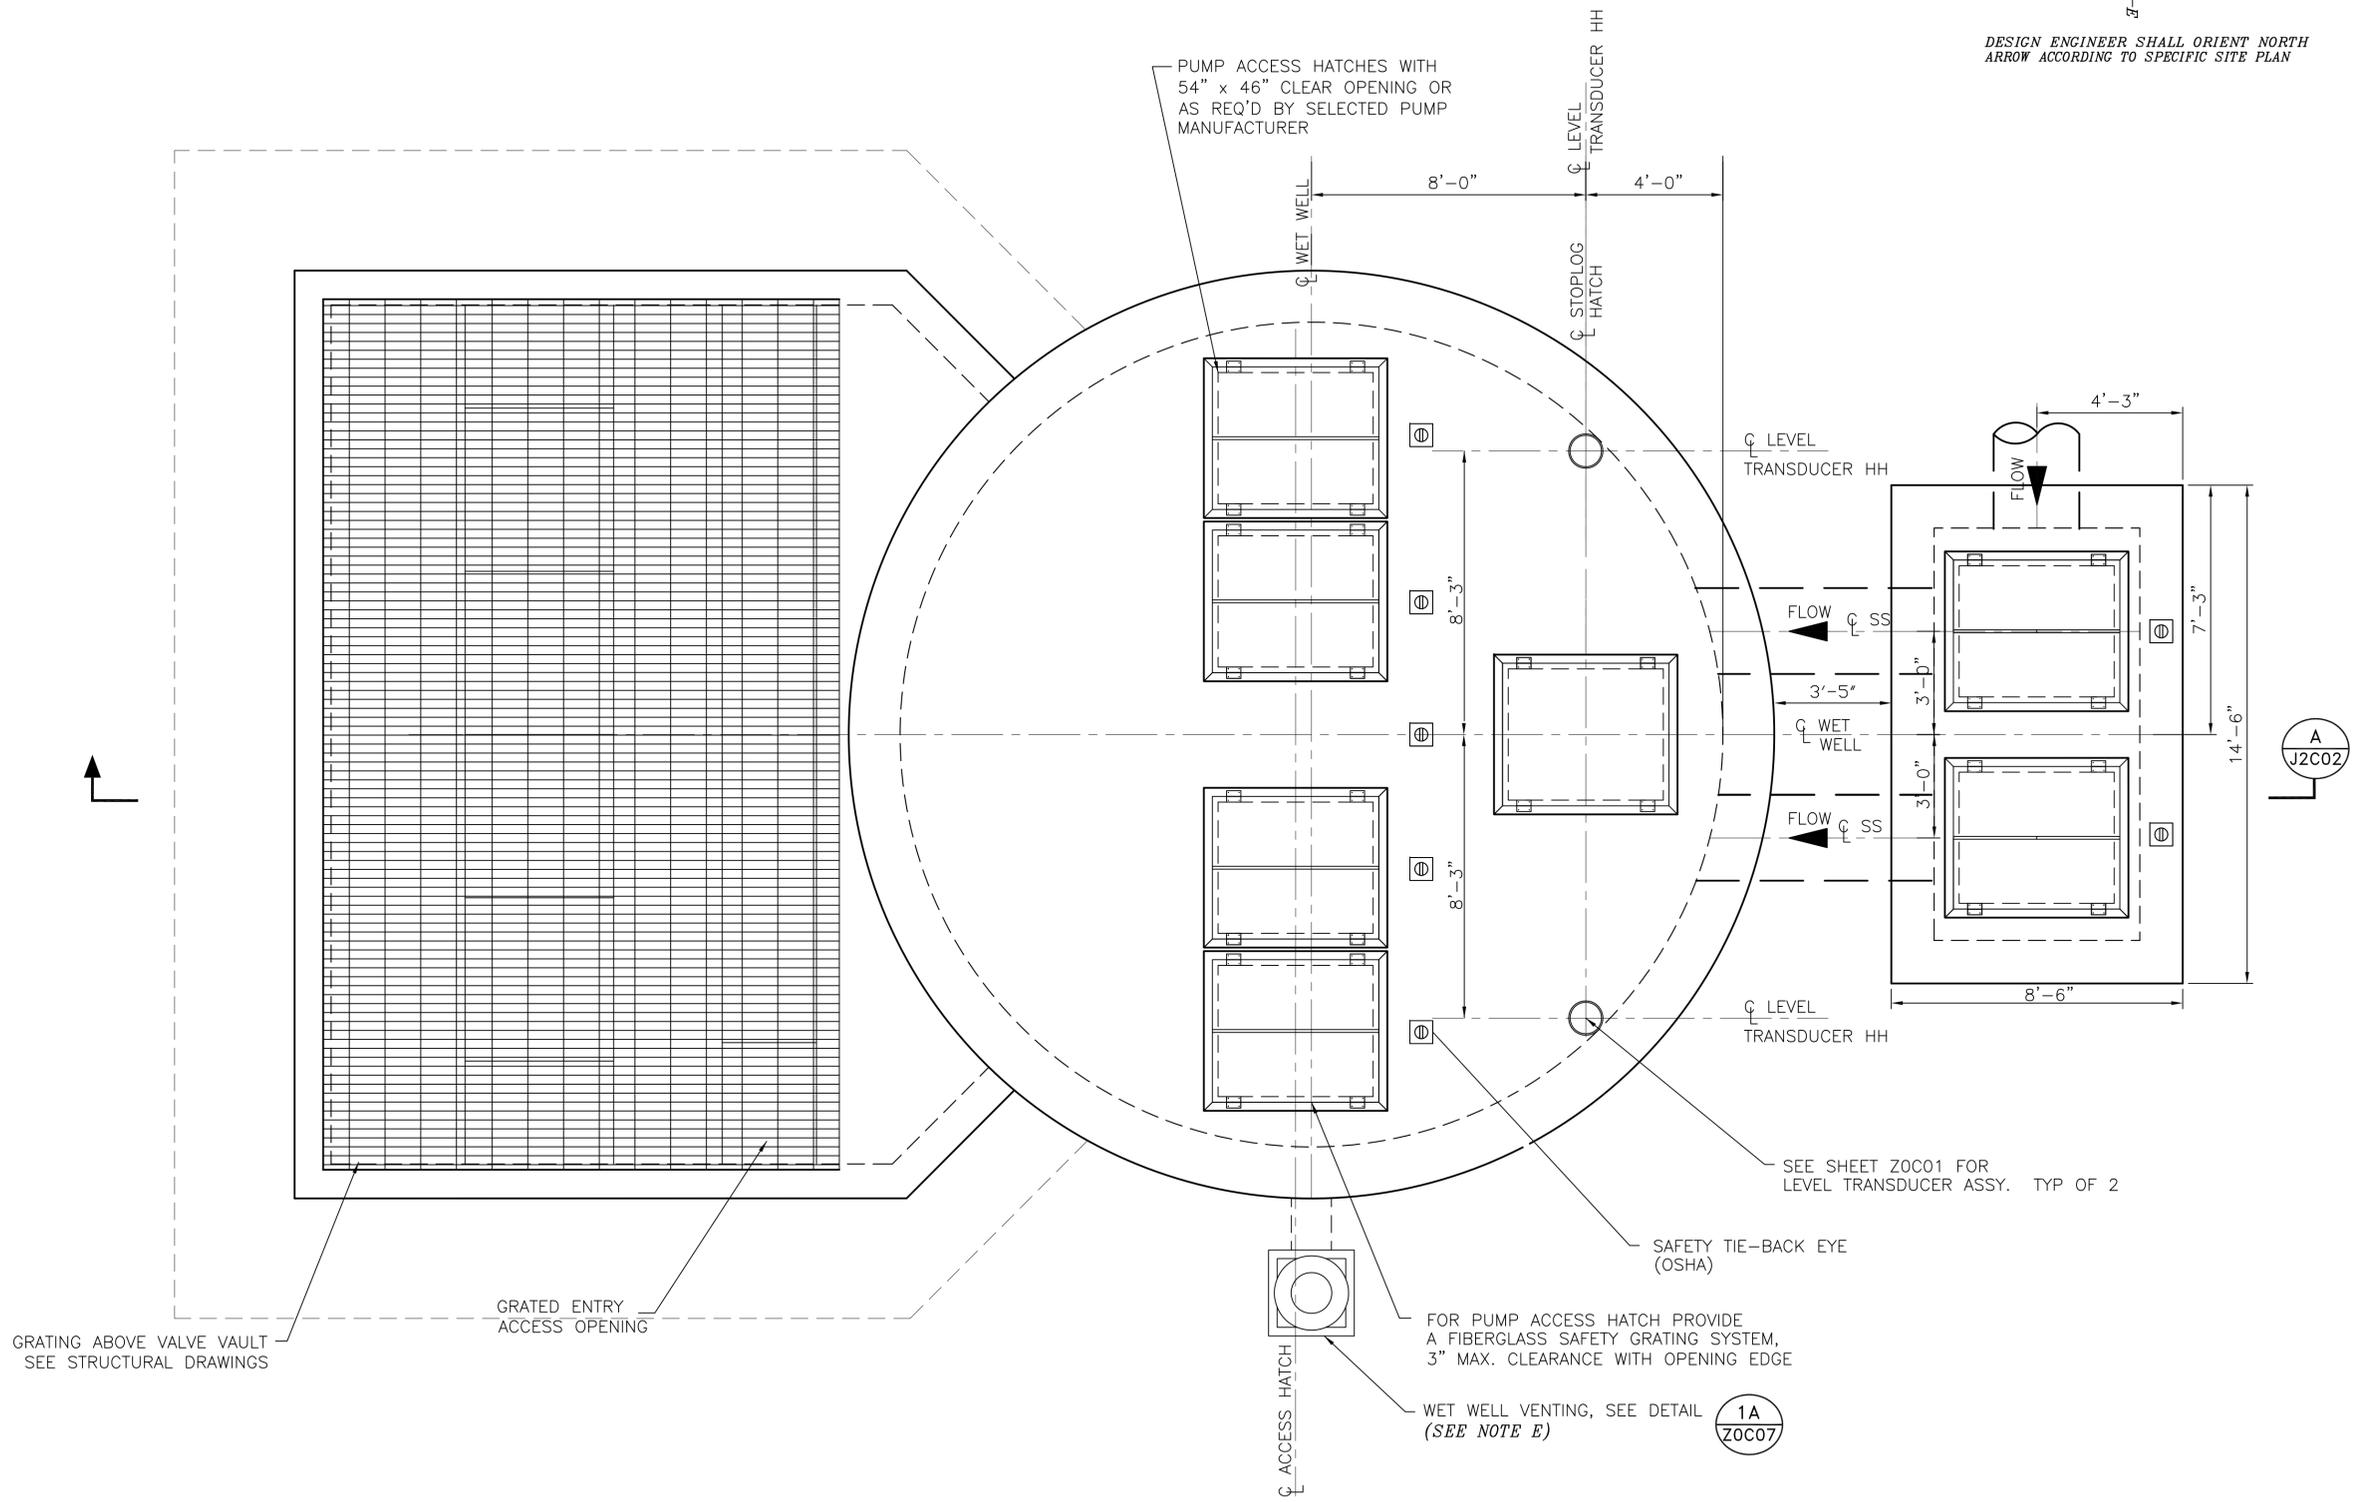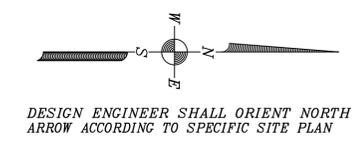

- NOTES TO DESIGN ENGINEER:**
- A. THESE LIFT STATION DRAWINGS ARE CONSIDERED TO BE DESIGN GUIDELINES FOR THE CONSTRUCTION OF CITY OF HOUSTON WASTEWATER SUBMERSIBLE LIFT STATIONS. THEIR INTENDED USE IS AS A FRAMEWORK FOR THE CONTRACTED DESIGN ENGINEER IN DEVELOPING SPECIFIC LIFT STATION DESIGNS. IT IS THE RESPONSIBILITY OF THE CONTRACTED DESIGN ENGINEER TO VERIFY THE COMPLETENESS AND ACCURACY OF THE INFORMATION HEREIN CONTAINED AND TO ADJUST ACCORDING TO PROJECT SPECIFIC REQUIREMENTS.
 - B. THIS DESIGN IS BASED UPON THE LARGEST CAPACITY PUMP FOR THIS STANDARD (RANGE: 800 - 3499 GPM PER PUMP).
 - C. LIFT STATION DESIGN IS BASED UPON 10"-20" NOMINAL PUMP, VALVES AND PIPING AS THE SIZES RECOMMENDED FOR THIS STANDARD STATION. THE DESIGN WILL ACCOMMODATE VALVES AND PIPING IF PROJECT SPECIFIC CONDITIONS REQUIRE.
 - D. DESIGN ENGINEER TO VERIFY THE SIZE AND LOCATION OF THE WET WELL HATCHES ACCORDING TO THE SELECTED HATCH AND PUMP MANUFACTURERS' REQUIREMENTS.
 - E. THE ACTUAL LOCATION OF THE WET WELL VENTING MAY VARY ACCORDING TO SITE REQUIREMENTS. WHERE POSSIBLE, LOCATE ON THE NORTHWEST SIDE OF THE WET WELL.
 - F. SEE DETAIL AND STRUCTURAL DRAWINGS FOR DIMENSIONS AND INFORMATION NOT SHOWN.
 - G. THE DESIGN ENGINEER SHALL INCORPORATE ONLY THE NECESSARY STANDARD GUIDELINE DRAWINGS AND DETAILS INTO HIS PROJECT CONTRACT DOCUMENTATION PACKAGE, AND SHALL ADJUST PAGE NUMBERS AND CROSS REFERENCING ACCORDINGLY.
 - H. THE DESIGN ENGINEER SHALL CONSULT THE CITY OF HOUSTON DESIGN GUIDELINES MANUAL, THE ENGINEERING DESIGN MANUAL, AND THE MASTER SPECIFICATIONS FOR FURTHER INSTRUCTIONS AND INFORMATION PERTINENT TO THESE STANDARD DESIGN GUIDELINE DRAWINGS.
 - I. THE DESIGN ENGINEER SHALL REMOVE THESE NOTES, ALL REFERENCES TO THESE NOTES, AND ANY OTHER EXTRANEOUS INFORMATION FROM THE DESIGN GUIDELINE DRAWINGS. DESIGN ENGINEER SHALL PROVIDE ANY NOTES OR OTHER APPROPRIATE INFORMATION NECESSARY TO COMPLETE THE LIFT STATION DESIGN.

- NOTES:**
1. SEE DETAIL AND STRUCTURAL DRAWINGS FOR DIMENSIONS AND INFORMATION NOT SHOWN.
 2. CONTRACTOR TO CONFIRM SIZE AND LOCATION OF THE WET WELL HATCHES PER SELECTED HATCH AND PUMP MANUFACTURERS' REQUIREMENTS.

PLAN VIEW @ GRADE
 4 PUMPS @ 800 - 3499 GPM PER PUMP
 PREFERRED CONFIGURATION

PROJECT NO. R-000267-0XXX-X

TITLE CITY OF HOUSTON
 DESIGN GUIDELINE DRAWINGS
 FOR SUBMERSIBLE LIFT STATIONS

CITY OF HOUSTON
 DEPARTMENT OF PUBLIC WORKS AND ENGINEERING
 ENGINEERING AND CONSTRUCTION

DESIGN ENGINEER TO INCLUDE COH STANDARD TITLE BLOCK ON ALL DRAWINGS, SEE STANDARD TITLE BLOCK DETAIL ON SHEET ZOC0X

PLAN VIEW @ GRADE


| REV. NO. | DESCRIPTION | APP'D | DATE |
|----------|-------------|-------|------|
| | | | |
| | | | |
| | | | |

| | |
|--------------------|---------------------|
| SCALE: XX" = 1'-0" | DESIGNED BY: |
| SUBMITTED: | DRAWN BY: |
| DATE: MARCH, 2013 | SHEET NO. OF SHEETS |
| SURVEY BY: | DWG. NO. J2C01 |
| FIELD BOOK NO. | |


CADD DWG. FILE NO. : J2C01.DWG

COHSTD.BDR 0 1 2 3


ORIGINAL SCALE IN INCHES FOR REDUCED PLANS DESIGN ENGINEER TO UPDATE BAR SCALE TO REFLECT ACTUAL SCALE ON THE DRAWING.

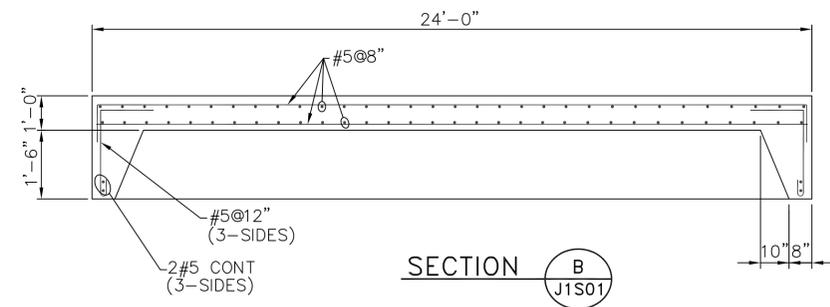


HATCH OPNG FRAME, TYP
SEE STD DET, SHT ZOS02

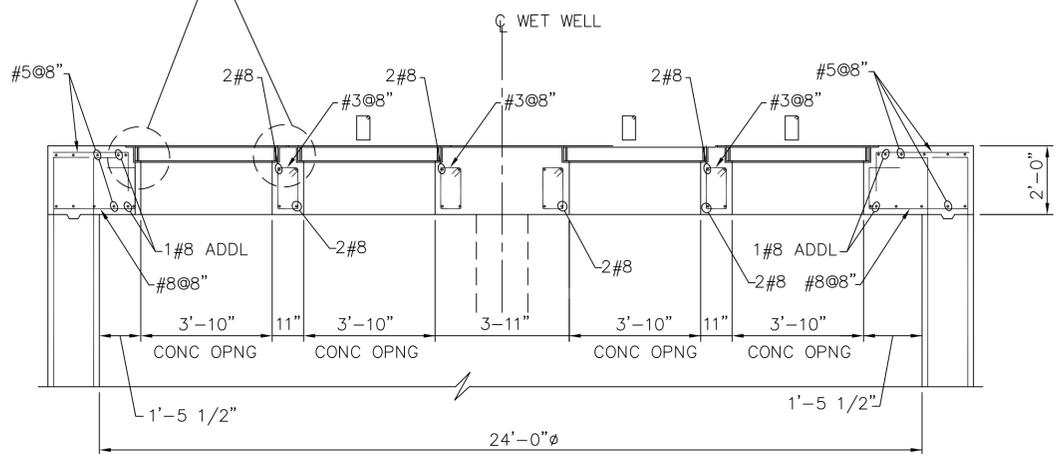

SECTION C
J1S01

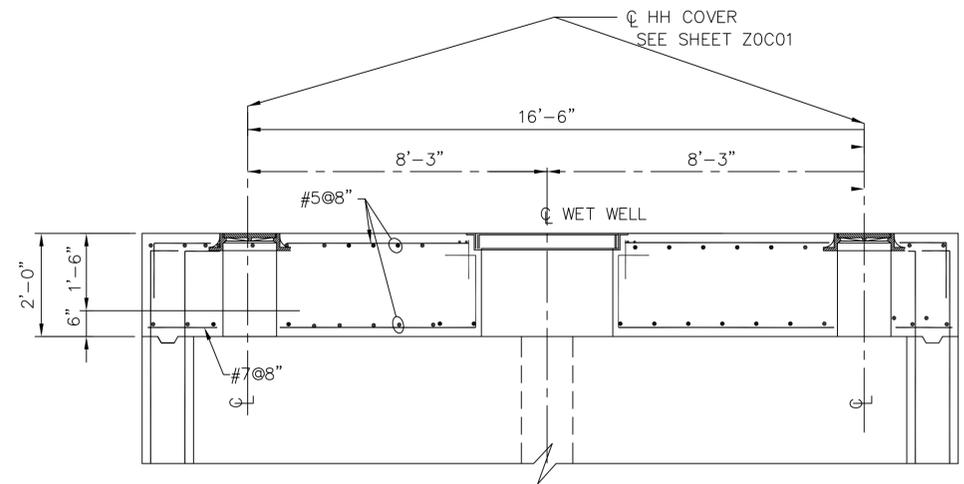

SECTION D
J1S01

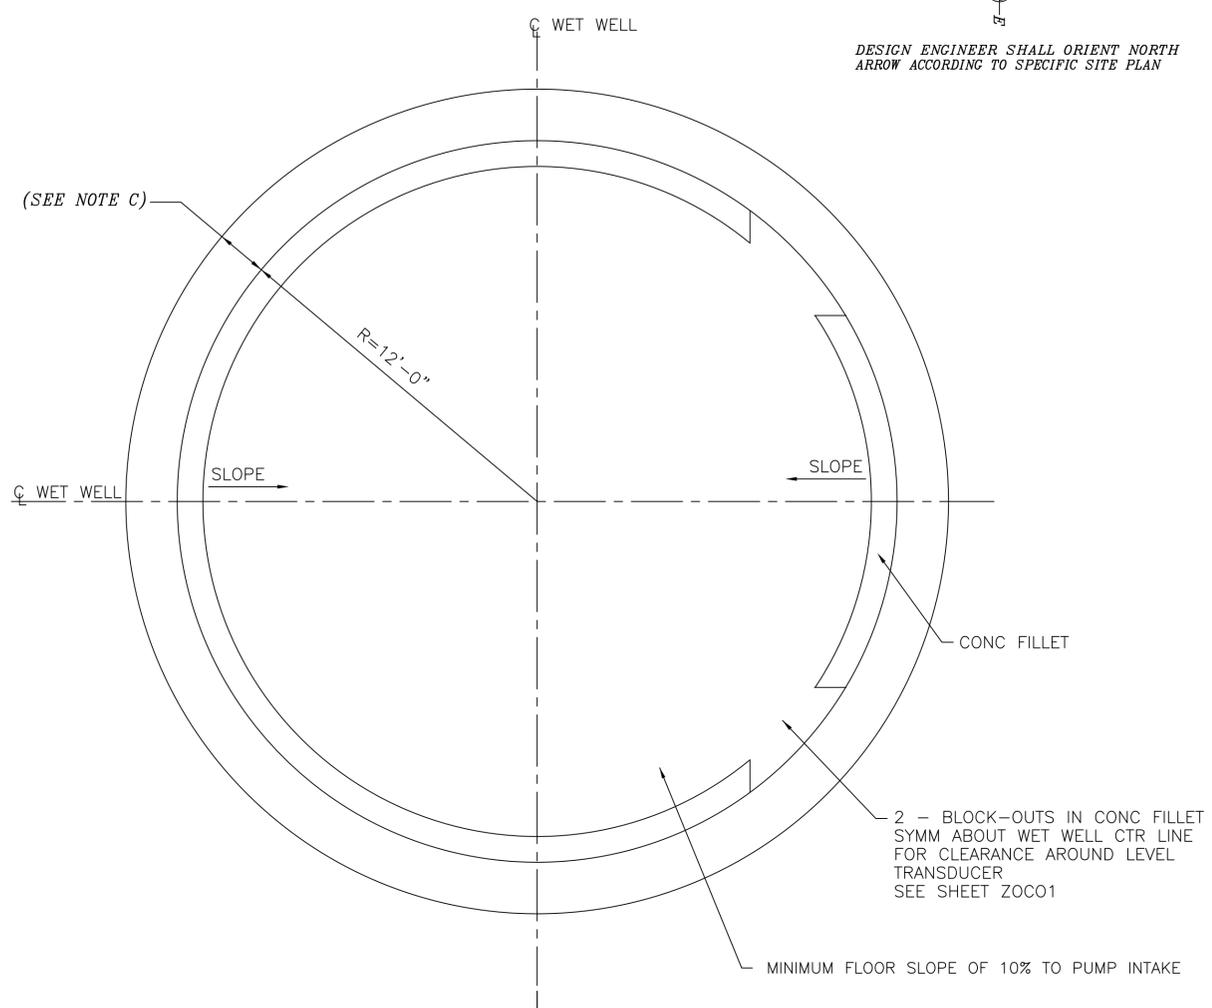

BASE SLAB PLAN

NOTES TO DESIGN ENGINEER:

A. THESE LIFT STATION DRAWINGS ARE CONSIDERED TO BE DESIGN GUIDELINES FOR THE CONSTRUCTION OF CITY OF HOUSTON WASTEWATER SUBMERSIBLE LIFT STATIONS. THEIR INTENDED USE IS AS A FRAMEWORK FOR THE CONTRACTED DESIGN ENGINEER IN DEVELOPING SPECIFIC LIFT STATION DESIGNS. IT IS THE RESPONSIBILITY OF THE CONTRACTED DESIGN ENGINEER TO VERIFY THE COMPLETENESS AND ACCURACY OF THE INFORMATION HEREIN CONTAINED AND TO ADJUST ACCORDING TO PROJECT SPECIFIC REQUIREMENTS.

B. DESIGN ENGINEER TO VERIFY SIZE AND LOCATION OF THE ACCESS HATCH OPENINGS PER SELECTED HATCH AND PUMP MANUFACTURERS' REQUIREMENTS.

C. DIMENSIONS AND REINFORCING NOT PROVIDED ARE TO BE DETERMINED BY THE DESIGN ENGINEER PER APPLICABLE PROJECT SPECIFIC REQUIREMENTS.

D. SEE DETAIL AND CIVIL DRAWINGS FOR DIMENSIONS AND INFORMATION NOT SHOWN.

E. THE DESIGN ENGINEER SHALL INCORPORATE ONLY THE NECESSARY STANDARD GUIDELINE DRAWINGS AND DETAILS INTO HIS PROJECT CONTRACT DOCUMENTATION PACKAGE, AND SHALL ADJUST PAGE NUMBERS AND CROSS REFERENCING ACCORDINGLY.

F. THE DESIGN ENGINEER SHALL CONSULT THE CITY OF HOUSTON DESIGN GUIDELINES MANUAL, THE ENGINEERING DESIGN MANUAL, AND THE MASTER SPECIFICATIONS FOR FURTHER INSTRUCTIONS AND INFORMATION PERTINENT TO THESE STANDARD DESIGN GUIDELINE DRAWINGS.

G. THE DESIGN ENGINEER SHALL REMOVE THESE NOTES, ALL REFERENCES TO THESE NOTES, AND ANY OTHER EXTRANEOUS INFORMATION FROM THE DESIGN GUIDELINE DRAWINGS. DESIGN ENGINEER SHALL PROVIDE ANY NOTES OR OTHER APPROPRIATE INFORMATION NECESSARY TO COMPLETE THE LIFT STATION DESIGN.


- NOTES:**
- FOR ADDITIONAL REINFORCEMENT AT OPENINGS NOT SHOWN, SEE SHEET ZOS01.
 - CONTRACTOR TO CONFIRM SIZE AND LOCATION OF THE ACCESS HATCH OPENINGS PER SELECTED HATCH AND PUMP MANUFACTURERS' REQUIREMENTS.
 - DIMENSIONS NOTED ARE RELATIVE TO THE PUMP SIZE AND MANUFACTURER SELECTED. CONTRACTOR SHALL CONFIRM.
 - SEE DETAIL AND CIVIL DRAWINGS FOR DIMENSIONS AND INFORMATION NOT SHOWN.
 - WET WELL TO BE LINED WITH CONCRETE PROTECTIVE LINER PER PROJECT SPECIFICATIONS, CONSULT WITH COH PROJECT MANAGER FOR APPROVED PRODUCTS. LINER SHALL COVER ALL CONCRETE SURFACES, AND SHALL EXTEND TO A MINIMUM OF 12" BELOW THE LOW WATER ELEVATION.

| | |
|--|---|
| STRUCTURAL | |
| 4 PUMPS @ 800 - 3499 GPM PER PUMP ALTERNATE HIGH PROFILE CONFIGURATION | |
| PROJECT NO. | R-000267-0XXX-X |
| TITLE | CITY OF HOUSTON DESIGN GUIDELINE DRAWINGS FOR SUBMERSIBLE LIFT STATIONS |
| CITY OF HOUSTON DEPARTMENT OF PUBLIC WORKS AND ENGINEERING ENGINEERING AND CONSTRUCTION | |

DESIGN ENGINEER TO INCLUDE COH STANDARD TITLE BLOCK ON ALL DRAWINGS, SEE STANDARD TITLE BLOCK DETAIL ON SHEET ZOC0X

| REV. NO. | DESCRIPTION | APP'D | DATE |
|----------|-------------|-------|------|
| | | | |
| | | | |
| | | | |
| | | | |

| | | | |
|----------------|-------------|----------------------|-------|
| SCALE: | XX" = 1'-0" | DESIGNED BY: | |
| SUBMITTED: | | DRAWN BY: | |
| DATE: | MARCH, 2013 | SHEET NO. OF SHEETS: | |
| SURVEY BY: | | DWG. NO. | J1S03 |
| FIELD BOOK NO. | | | |

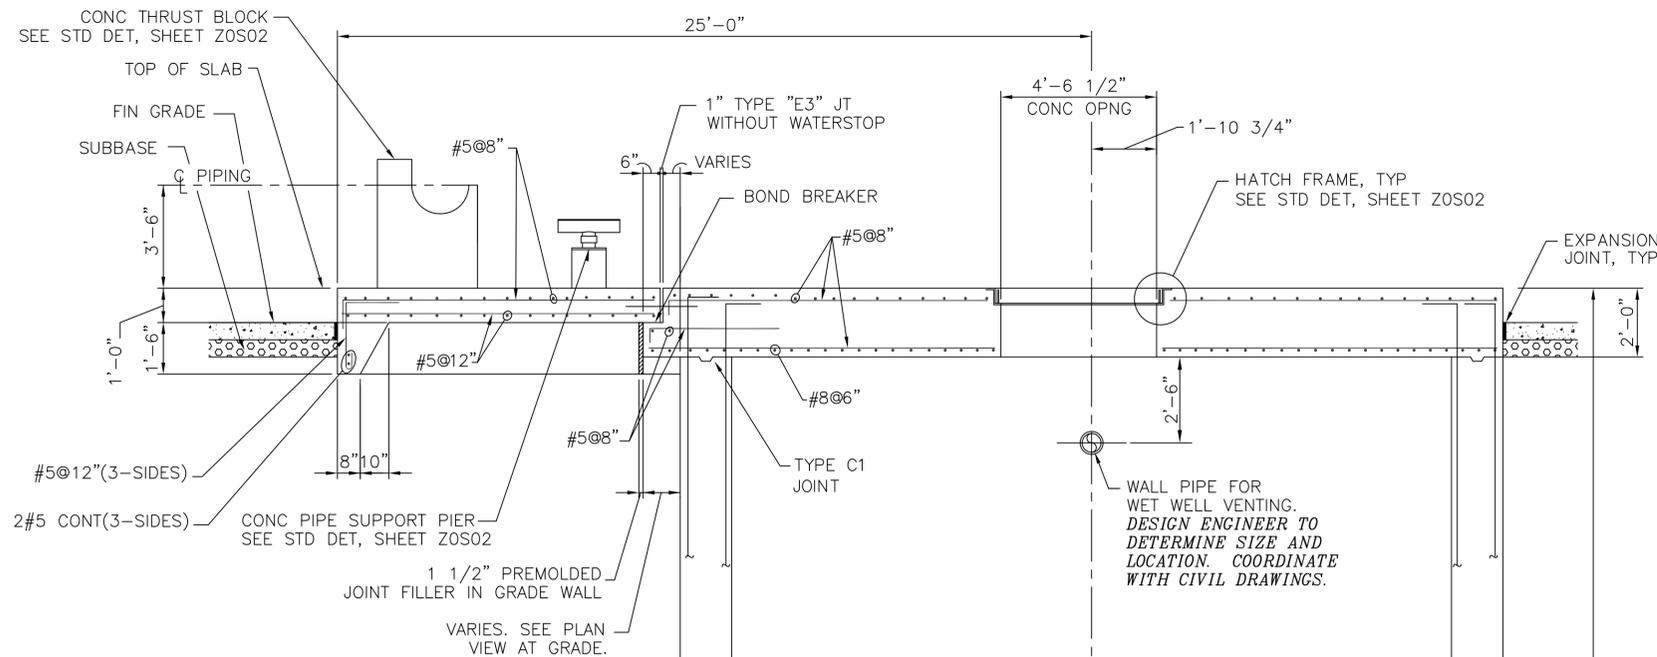

NOTES TO DESIGN ENGINEER:

A. THESE LIFT STATION DRAWINGS ARE CONSIDERED TO BE DESIGN GUIDELINES FOR THE CONSTRUCTION OF CITY OF HOUSTON WASTEWATER SUBMERSIBLE LIFT STATIONS. THEIR INTENDED USE IS AS A FRAMEWORK FOR THE CONTRACTED DESIGN ENGINEER IN DEVELOPING SPECIFIC LIFT STATION DESIGNS. IT IS THE RESPONSIBILITY OF THE CONTRACTED DESIGN ENGINEER TO VERIFY THE COMPLETENESS AND ACCURACY OF THE INFORMATION HEREIN CONTAINED AND TO ADJUST ACCORDING TO PROJECT SPECIFIC REQUIREMENTS.

B. DESIGN ENGINEER TO VERIFY SIZE AND LOCATION OF THE ACCESS HATCH OPENINGS PER SELECTED HATCH AND PUMP MANUFACTURERS' REQUIREMENTS.

C. SEE DETAIL AND CIVIL DRAWINGS FOR DIMENSIONS AND INFORMATION NOT SHOWN.

D. DIMENSIONS, ELEVATIONS AND REINFORCING NOT PROVIDED ARE TO BE DETERMINED BY THE DESIGN ENGINEER PER APPLICABLE PROJECT SPECIFIC REQUIREMENTS.

E. DESIGN ENGINEER TO PROVIDE WET WELL DESIGN FOR EITHER OPEN-CUT OR CAISSON CONSTRUCTION.

F. THE DESIGN ENGINEER SHALL INCORPORATE ONLY THE NECESSARY STANDARD GUIDELINE DRAWINGS AND DETAILS INTO HIS PROJECT CONTRACT DOCUMENTATION PACKAGE AND SHALL ADJUST PAGE NUMBERS AND CROSS REFERENCING ACCORDINGLY.

G. THE DESIGN ENGINEER SHALL CONSULT THE CITY OF HOUSTON DESIGN GUIDELINES MANUAL, THE ENGINEERING DESIGN MANUAL, AND THE MASTER SPECIFICATIONS FOR FURTHER INSTRUCTIONS AND INFORMATION PERTINENT TO THESE STANDARD DESIGN GUIDELINE DRAWINGS.

H. THE DESIGN ENGINEER SHALL REMOVE THESE NOTES, ALL REFERENCES TO THESE NOTES, AND ANY OTHER EXTRANEOUS INFORMATION FROM THE DESIGN GUIDELINE DRAWINGS. DESIGN ENGINEER SHALL PROVIDE ANY NOTES OR OTHER APPROPRIATE INFORMATION NECESSARY TO COMPLETE THE LIFT STATION DESIGN.

- NOTES:**
- FOR ADDITIONAL REINFORCEMENT AT OPENINGS NOT SHOWN, SEE SHEET ZOS01.
 - CONTRACTOR TO CONFIRM SIZE AND LOCATION OF THE ACCESS HATCH OPENINGS PER SELECTED HATCH AND PUMP MANUFACTURERS' REQUIREMENTS.
 - DIMENSIONS NOTED ARE RELATIVE TO THE PUMP SIZE AND MANUFACTURER SELECTED. CONTRACTOR SHALL CONFIRM.
 - SEE DETAIL AND CIVIL DRAWINGS FOR DIMENSIONS AND INFORMATION NOT SHOWN.
 - WET WELL TO BE LINED WITH CONCRETE PROTECTIVE LINER PER PROJECT SPECIFICATIONS, CONSULT WITH COH PROJECT MANAGER FOR APPROVED PRODUCTS. LINER SHALL COVER ALL CONCRETE SURFACES, AND SHALL EXTEND TO A MINIMUM OF 12" BELOW THE LOW WATER ELEVATION.


STRUCTURAL
 4 PUMPS @ 800 - 3499 GPM PER PUMP
 ALTERNATE HIGH PROFILE CONFIGURATION

PROJECT NO. R-000267-0XXX-X

TITLE CITY OF HOUSTON
 DESIGN GUIDELINE DRAWINGS
 FOR SUBMERSIBLE LIFT STATIONS

CITY OF HOUSTON
 DEPARTMENT OF PUBLIC WORKS AND ENGINEERING
 ENGINEERING AND CONSTRUCTION

DESIGN ENGINEER TO INCLUDE COH STANDARD TITLE BLOCK ON ALL DRAWINGS, SEE STANDARD TITLE BLOCK DETAIL ON SHEET ZOC0X

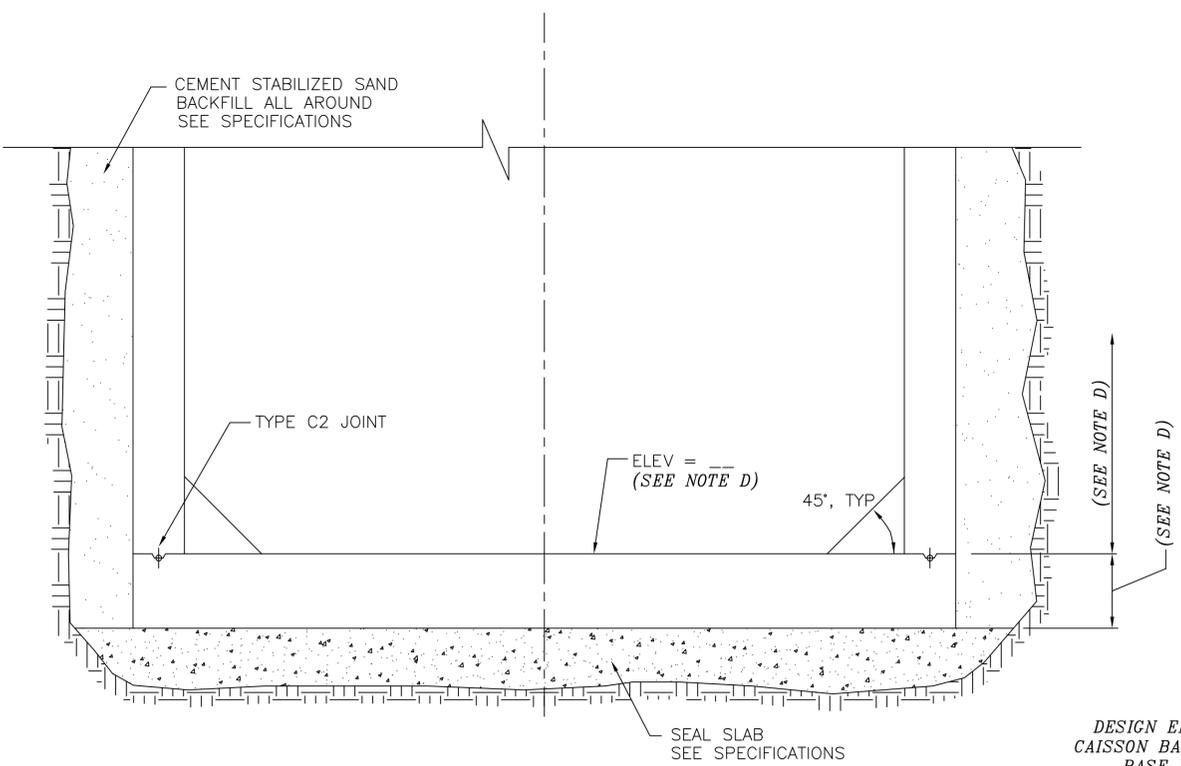

OPEN-CUT CONSTRUCTION OF WET WELL
 SEE NOTE E

DESIGN ENGINEER TO PROVIDE CAISSON BASE DESIGN, SEE TYP BASE DETAIL, SHEET ZOS01


CAISSON CONSTRUCTION OF WET WELL
 SEE NOTE E

SECTION A
 J1S01

| REV. NO. | DESCRIPTION | APP'D | DATE |
|----------|-------------|-------|------|
| | | | |
| | | | |
| | | | |
| | | | |
| | | | |

| | |
|--------------------|---------------------|
| SCALE: xx" = 1'-0" | DESIGNED BY: |
| SUBMITTED: | DRAWN BY: |
| DATE: MARCH, 2013 | SHEET NO. OF SHEETS |
| SURVEY BY: | DWG. NO. J1S02 |
| FIELD BOOK NO. | |

CADD DWG. FILE NO. : J1S02.DWG

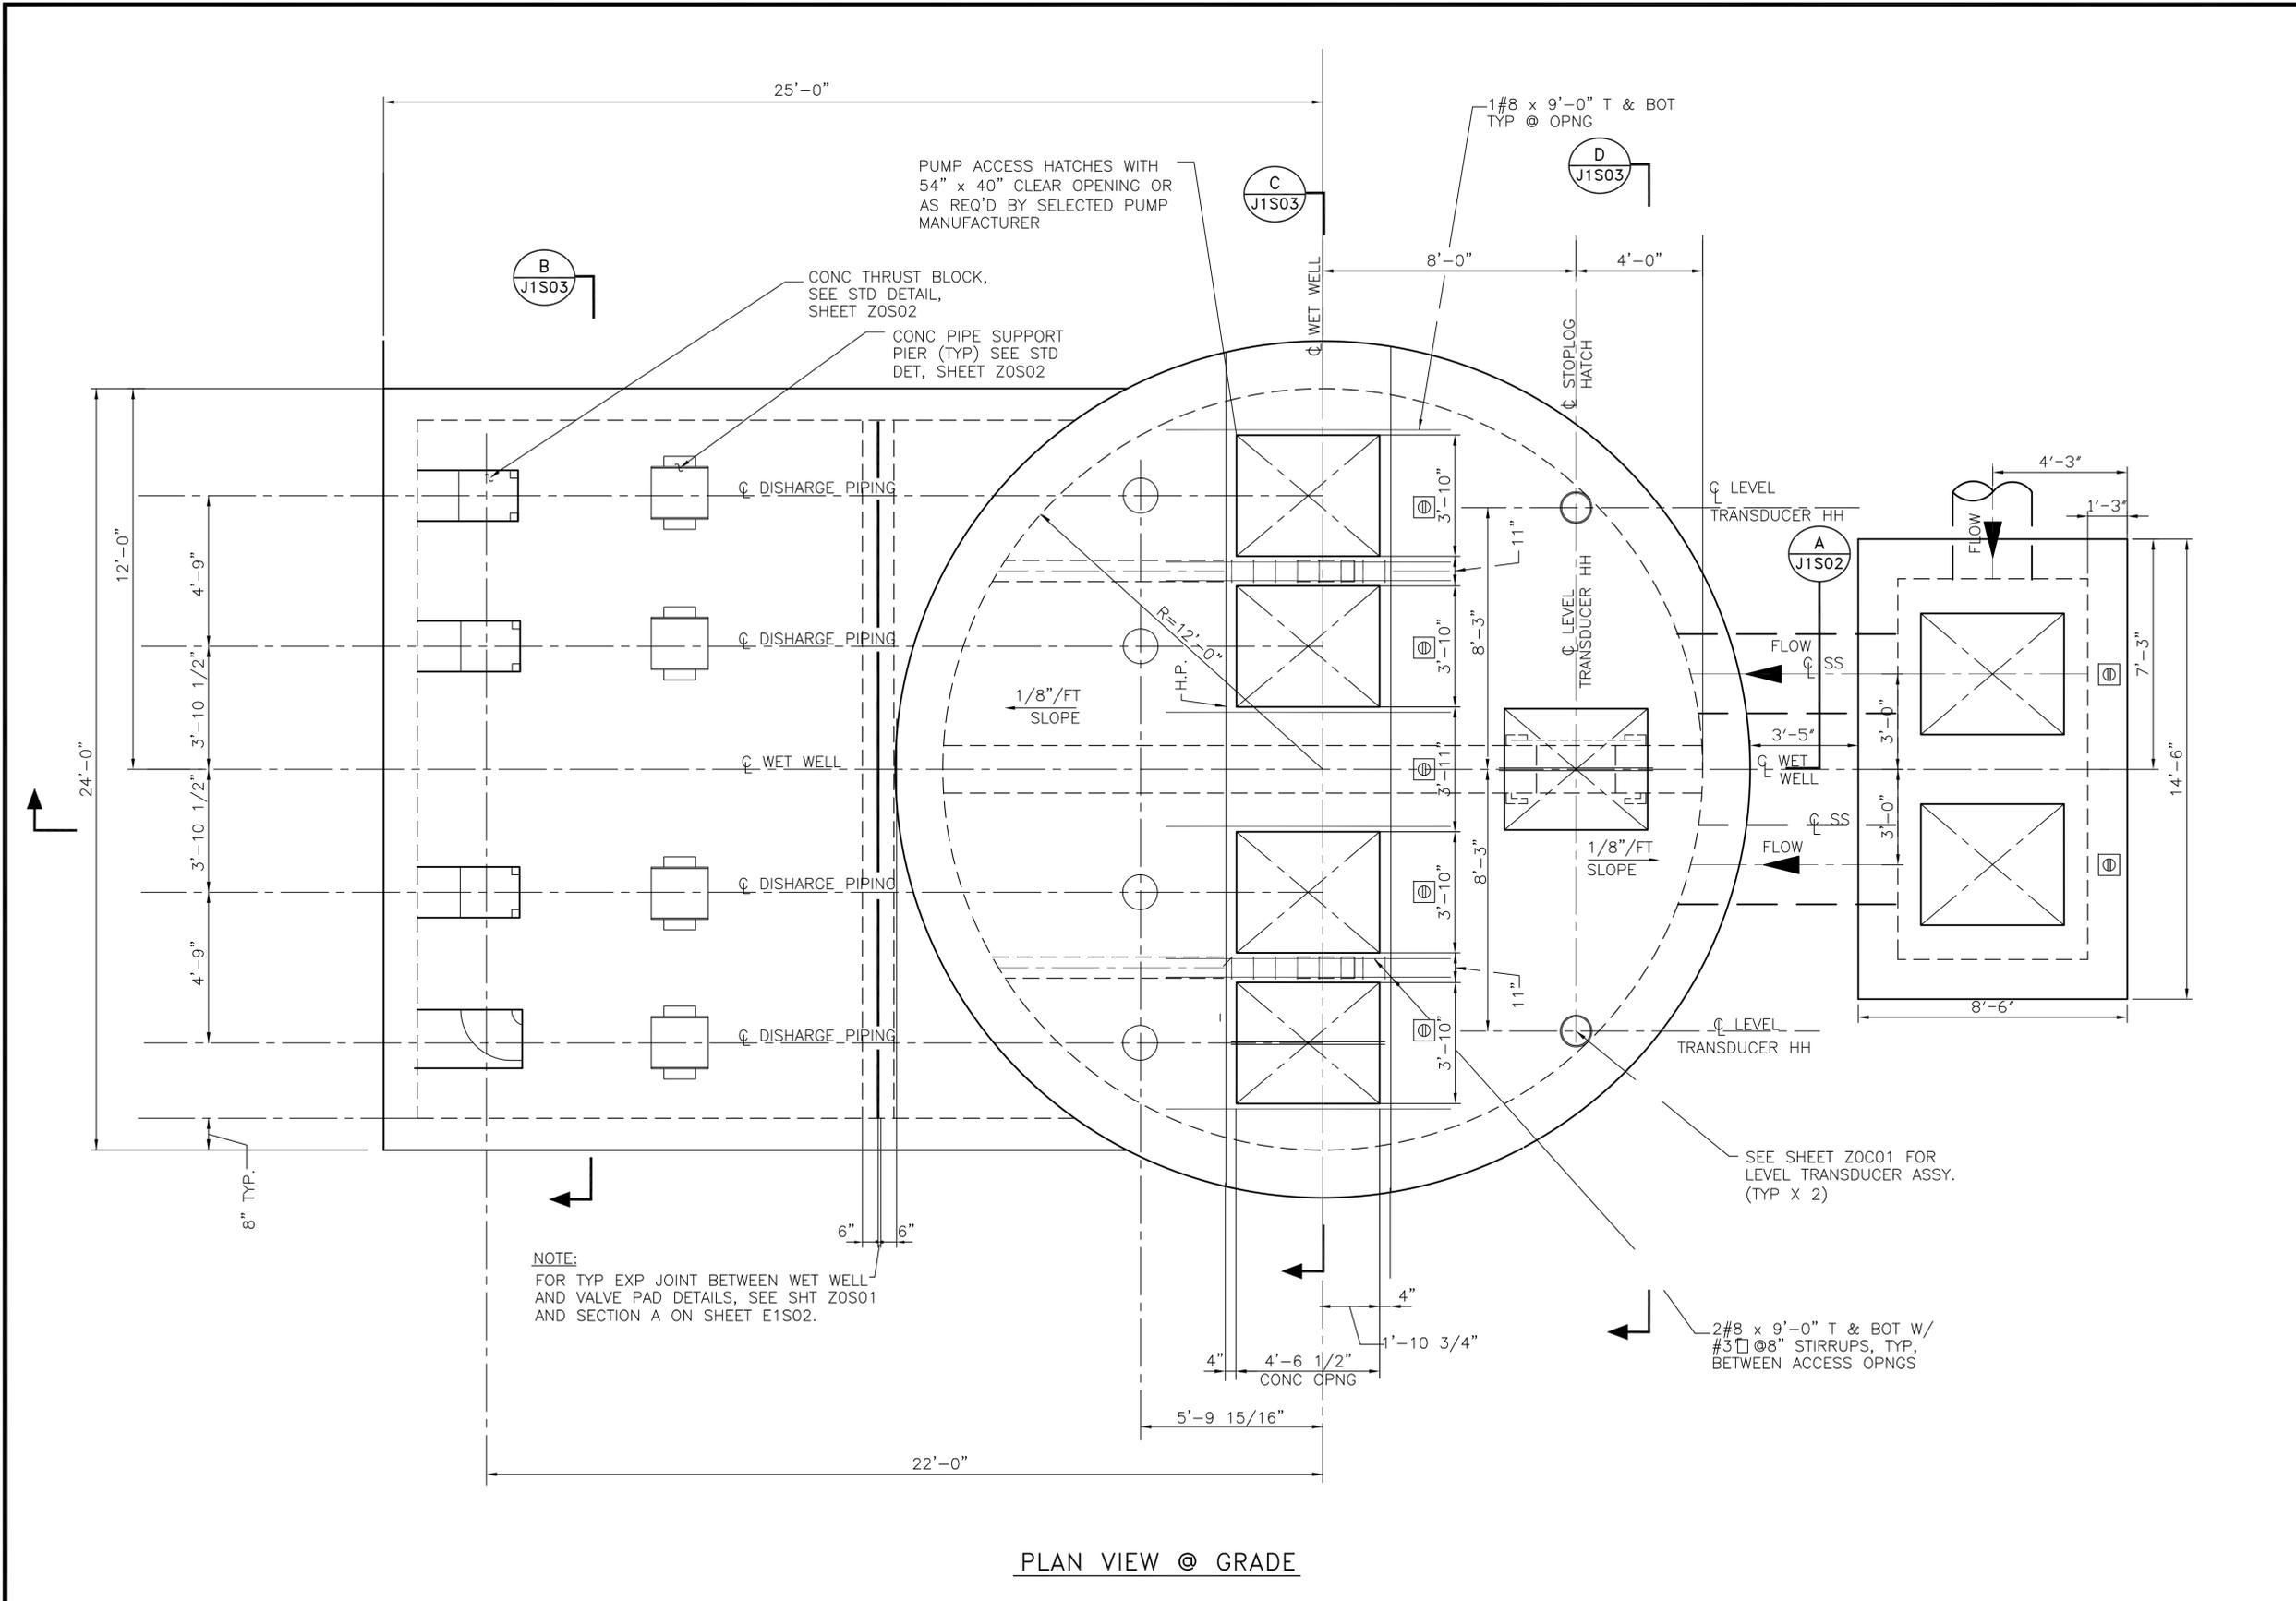

PLAN VIEW @ GRADE

NOTES TO DESIGN ENGINEER:

A. THESE LIFT STATION DRAWINGS ARE CONSIDERED TO BE DESIGN GUIDELINES FOR THE CONSTRUCTION OF CITY OF HOUSTON WASTEWATER SUBMERSIBLE LIFT STATIONS. THEIR INTENDED USE IS AS A FRAMEWORK FOR THE CONTRACTED DESIGN ENGINEER IN DEVELOPING SPECIFIC LIFT STATION DESIGNS. IT IS THE RESPONSIBILITY OF THE CONTRACTED DESIGN ENGINEER TO VERIFY THE COMPLETENESS AND ACCURACY OF THE INFORMATION HEREIN CONTAINED AND TO ADJUST ACCORDING TO PROJECT SPECIFIC REQUIREMENTS.

B. DESIGN ENGINEER TO VERIFY SIZE AND LOCATION OF THE ACCESS HATCH OPENINGS PER SELECTED HATCH AND PUMP MANUFACTURERS' REQUIREMENTS.

C. DIMENSIONS AND REINFORCING NOT PROVIDED ARE TO BE DETERMINED BY THE DESIGN ENGINEER PER APPLICABLE PROJECT SPECIFIC REQUIREMENTS.

D. SEE DETAIL AND CIVIL DRAWINGS FOR DIMENSIONS AND INFORMATION NOT SHOWN.

E. THE DESIGN ENGINEER SHALL INCORPORATE ONLY THE NECESSARY STANDARD GUIDELINE DRAWINGS AND DETAILS INTO HIS PROJECT CONTRACT DOCUMENTATION PACKAGE, AND SHALL ADJUST PAGE NUMBERS AND CROSS REFERENCING ACCORDINGLY.

F. THE DESIGN ENGINEER SHALL CONSULT THE CITY OF HOUSTON DESIGN GUIDELINES MANUAL, THE ENGINEERING DESIGN MANUAL, AND THE MASTER SPECIFICATIONS FOR FURTHER INSTRUCTIONS AND INFORMATION PERTINENT TO THESE STANDARD DESIGN GUIDELINE DRAWINGS.

G. THE DESIGN ENGINEER SHALL REMOVE THESE NOTES, ALL REFERENCES TO THESE NOTES, AND ANY OTHER EXTRANEOUS INFORMATION FROM THE DESIGN GUIDELINE DRAWINGS. DESIGN ENGINEER SHALL PROVIDE ANY NOTES OR OTHER APPROPRIATE INFORMATION NECESSARY TO COMPLETE THE LIFT STATION DESIGN.

H. THE DESIGN ENGINEER SHALL ENSURE GUARDRAIL AND CATWALK MEET THE REQUIREMENTS FOR "AREAS NOT OPEN TO PUBLIC" AS PROVIDED BY THE U.S. OCCUPATIONAL SAFETY & HEALTH ADMINISTRATION (OSHA) AND LATEST COH CODE ENFORCEMENT APPROVED VERSION OF THE INTERNATIONAL BUILDING CODE (IBC).

I. THE DESIGN ENGINEER SHALL PROVIDE GUARDRAILS FOR ANY WALKING SURFACES WITH A POTENTIAL FALL DISTANCE EQUAL TO OR GREATER THAN 30 INCHES.

- NOTES:**
- FOR ADDITIONAL REINFORCEMENT AT OPENINGS NOT SHOWN, SEE SHEET ZOS01.
 - CONTRACTOR TO CONFIRM SIZE AND LOCATION OF THE WET WELL HATCHES PER HATCH AND PUMP MANUFACTURER'S REQUIREMENTS.
 - SEE DETAIL AND STRUCTURAL DRAWINGS FOR DIMENSIONS AND INFORMATION NOT SHOWN.
 - SEE DETAIL AND CIVIL DRAWINGS FOR DIMENSIONS AND INFORMATION NOT SHOWN.
 - WET WELL TO BE LINED WITH CONCRETE PROTECTIVE LINER PER PROJECT SPECIFICATIONS, CONSULT WITH COH PROJECT MANAGER FOR APPROVED PRODUCTS. LINER SHALL COVER ALL CONCRETE SURFACES, AND SHALL EXTEND TO A MINIMUM OF 12" BELOW THE LOW WATER ELEVATION.

STRUCTURAL
 4 PUMPS @ 800 - 3499 GPM PER PUMP
 ALTERNATE HIGH PROFILE CONFIGURATION

PROJECT NO. R-0000267-0XXX-X

TITLE CITY OF HOUSTON
 DESIGN GUIDELINE DRAWINGS
 FOR SUBMERSIBLE LIFT STATIONS

CITY OF HOUSTON
 DEPARTMENT OF PUBLIC WORKS AND ENGINEERING
 ENGINEERING AND CONSTRUCTION

DESIGN ENGINEER TO INCLUDE COH STANDARD TITLE BLOCK ON ALL DRAWINGS, SEE STANDARD TITLE BLOCK DETAIL ON SHEET ZOC0X

| REV. NO. | DESCRIPTION | APP'D | DATE |
|----------|-------------|-------|------|
| | | | |
| | | | |
| | | | |
| | | | |

SCALE: XX" = 1'-0"
 DESIGNED BY:
 SUBMITTED: DRAWN BY:
 DATE: MARCH, 2013 SHEET NO. OF SHEETS
 SURVEY BY: DWG. NO. J1S01
 FIELD BOOK NO.

CADD DWG. FILE NO. : J1S01.DWG

NOTES TO DESIGN ENGINEER:

- A. THESE LIFT STATION DRAWINGS ARE CONSIDERED TO BE DESIGN GUIDELINES FOR THE CONSTRUCTION OF CITY OF HOUSTON WASTEWATER SUBMERSIBLE LIFT STATIONS. THEIR INTENDED USE IS AS A FRAMEWORK FOR THE CONTRACTED DESIGN ENGINEER IN DEVELOPING SPECIFIC LIFT STATION DESIGNS. IT IS THE RESPONSIBILITY OF THE CONTRACTED DESIGN ENGINEER TO VERIFY THE COMPLETENESS AND ACCURACY OF THE INFORMATION HEREIN CONTAINED AND TO ADJUST ACCORDING TO PROJECT SPECIFIC REQUIREMENTS.
- B. THIS DESIGN IS BASED UPON THE LARGEST CAPACITY PUMP FOR THIS STANDARD (RANGE: 800 - 3499 GPM PER PUMP).
- C. LIFT STATION DESIGN IS BASED UPON 10"-20" NOMINAL PUMP VALVES AND PIPING AS THE SIZES RECOMMENDED FOR THIS STANDARD STATION. THE DESIGN WILL ACCOMMODATE VALVES AND PIPING IF PROJECT SPECIFIC CONDITIONS REQUIRE.
- D. DIMENSIONS NOTED ARE RELATIVE TO THE PUMP SIZE AND MANUFACTURER SELECTED. DESIGN ENGINEER SHALL VERIFY.
- E. SEE DETAIL AND STRUCTURAL DRAWINGS FOR DIMENSIONS AND INFORMATION NOT SHOWN.
- F. THE DESIGN ENGINEER SHALL INCORPORATE ONLY THE NECESSARY STANDARD GUIDELINE DRAWINGS AND DETAILS INTO HIS PROJECT CONTRACT DOCUMENTATION PACKAGE, AND SHALL ADJUST PAGE NUMBERS AND CROSS REFERENCING ACCORDINGLY.
- G. THE DESIGN ENGINEER SHALL CONSULT THE CITY OF HOUSTON DESIGN GUIDELINES MANUAL, THE ENGINEERING DESIGN MANUAL, AND THE MASTER SPECIFICATIONS FOR FURTHER INSTRUCTIONS AND INFORMATION PERTINENT TO THESE STANDARD DESIGN GUIDELINE DRAWINGS.
- H. THE DESIGN ENGINEER SHALL REMOVE THESE NOTES, ALL REFERENCES TO THESE NOTES, AND ANY OTHER EXTRANEOUS INFORMATION FROM THE DESIGN GUIDELINE DRAWINGS. DESIGN ENGINEER SHALL PROVIDE ANY NOTES OR OTHER APPROPRIATE INFORMATION NECESSARY TO COMPLETE THE LIFT STATION DESIGN.

NOTES:

- 1. SEE DETAIL AND STRUCTURAL DRAWINGS FOR DIMENSIONS AND INFORMATION NOT SHOWN.
- 2. DIMENSIONS NOTED ARE RELATIVE TO THE PUMP SIZE AND MANUFACTURER SELECTED. CONTRACTOR SHALL CONFIRM.

 
BASE SECTION
4 PUMPS @ 800 - 3499 GPM PER PUMP
ALTERNATE HIGH PROFILE CONFIGURATION

PROJECT NO. R-000267-0XXX-X


TITLE CITY OF HOUSTON
DESIGN GUIDELINE DRAWINGS
FOR SUBMERSIBLE LIFT STATIONS

CITY OF HOUSTON
DEPARTMENT OF PUBLIC WORKS AND ENGINEERING
ENGINEERING AND CONSTRUCTION

DESIGN ENGINEER TO INCLUDE COH STANDARD TITLE BLOCK ON ALL DRAWINGS, SEE STANDARD TITLE BLOCK DETAIL ON SHEET ZOC0X



DESIGN ENGINEER SHALL ORIENT NORTH ARROW ACCORDING TO SPECIFIC SITE PLAN

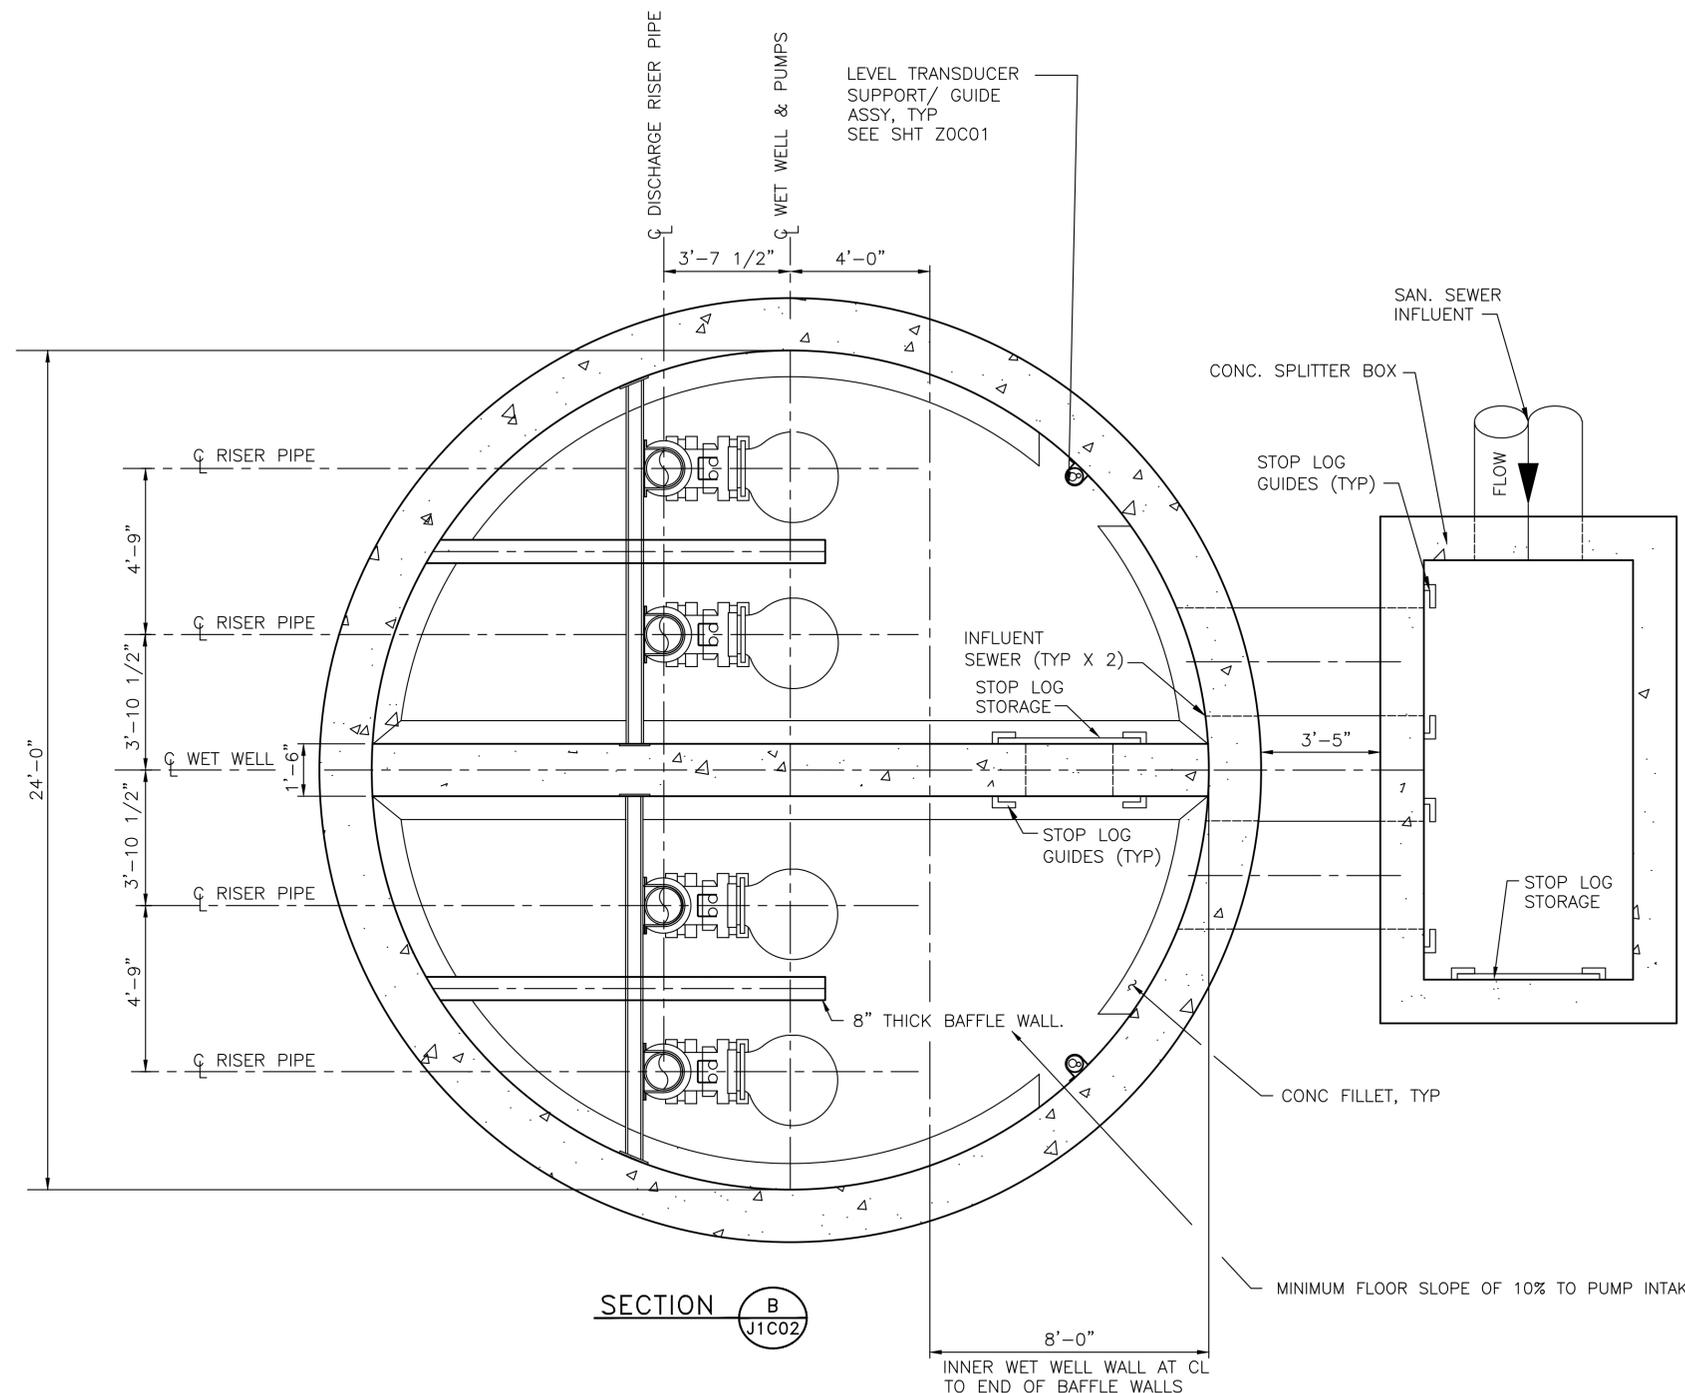

CADD DWG. FILE NO. : J1C03.DWG

| REV. NO. | DESCRIPTION | APP'D | DATE |
|----------|-------------|-------|------|
| | | | |
| | | | |
| | | | |
| | | | |

| | |
|--------------------|---------------------|
| SCALE: xx" = 1'-0" | DESIGNED BY: |
| SUBMITTED: | DRAWN BY: |
| DATE: MARCH, 2013 | SHEET NO. OF SHEETS |
| SURVEY BY: | DWG. NO. J1C03 |
| FIELD BOOK NO. | |

